

STATE OF HAWAII
DEPARTMENT OF LAND AND NATURAL RESOURCES
ENGINEERING DIVISION



FOR
DIVISION OF STATE PARKS

JOB NO. F46C602F

KOKE'E STATE PARK
ELECTRICAL IMPROVEMENTS

WAIMEA, KAUAI, HAWAII

TMK: (4th Division) 1-4-001:013

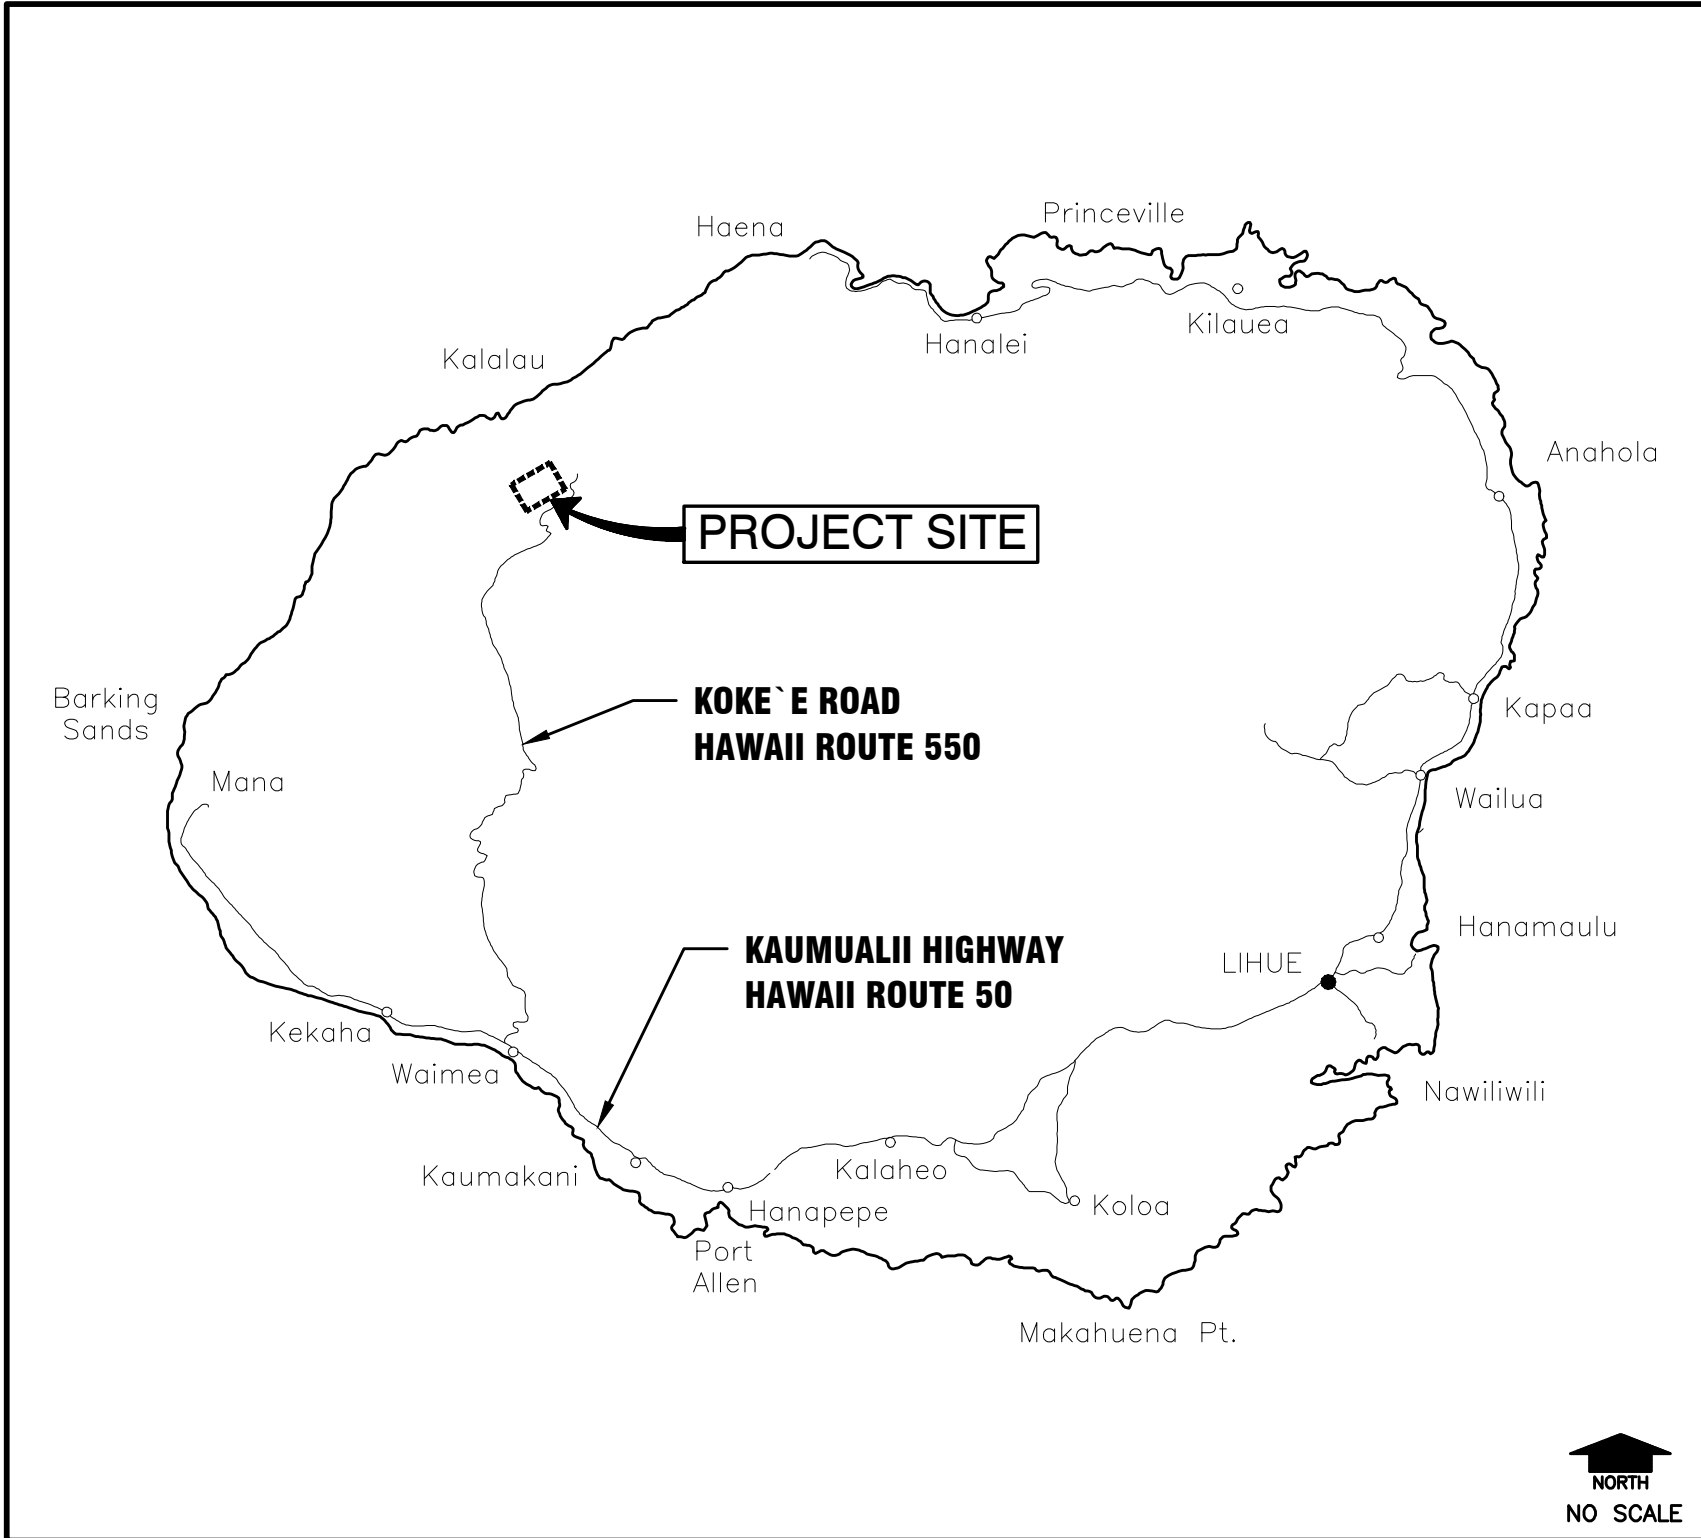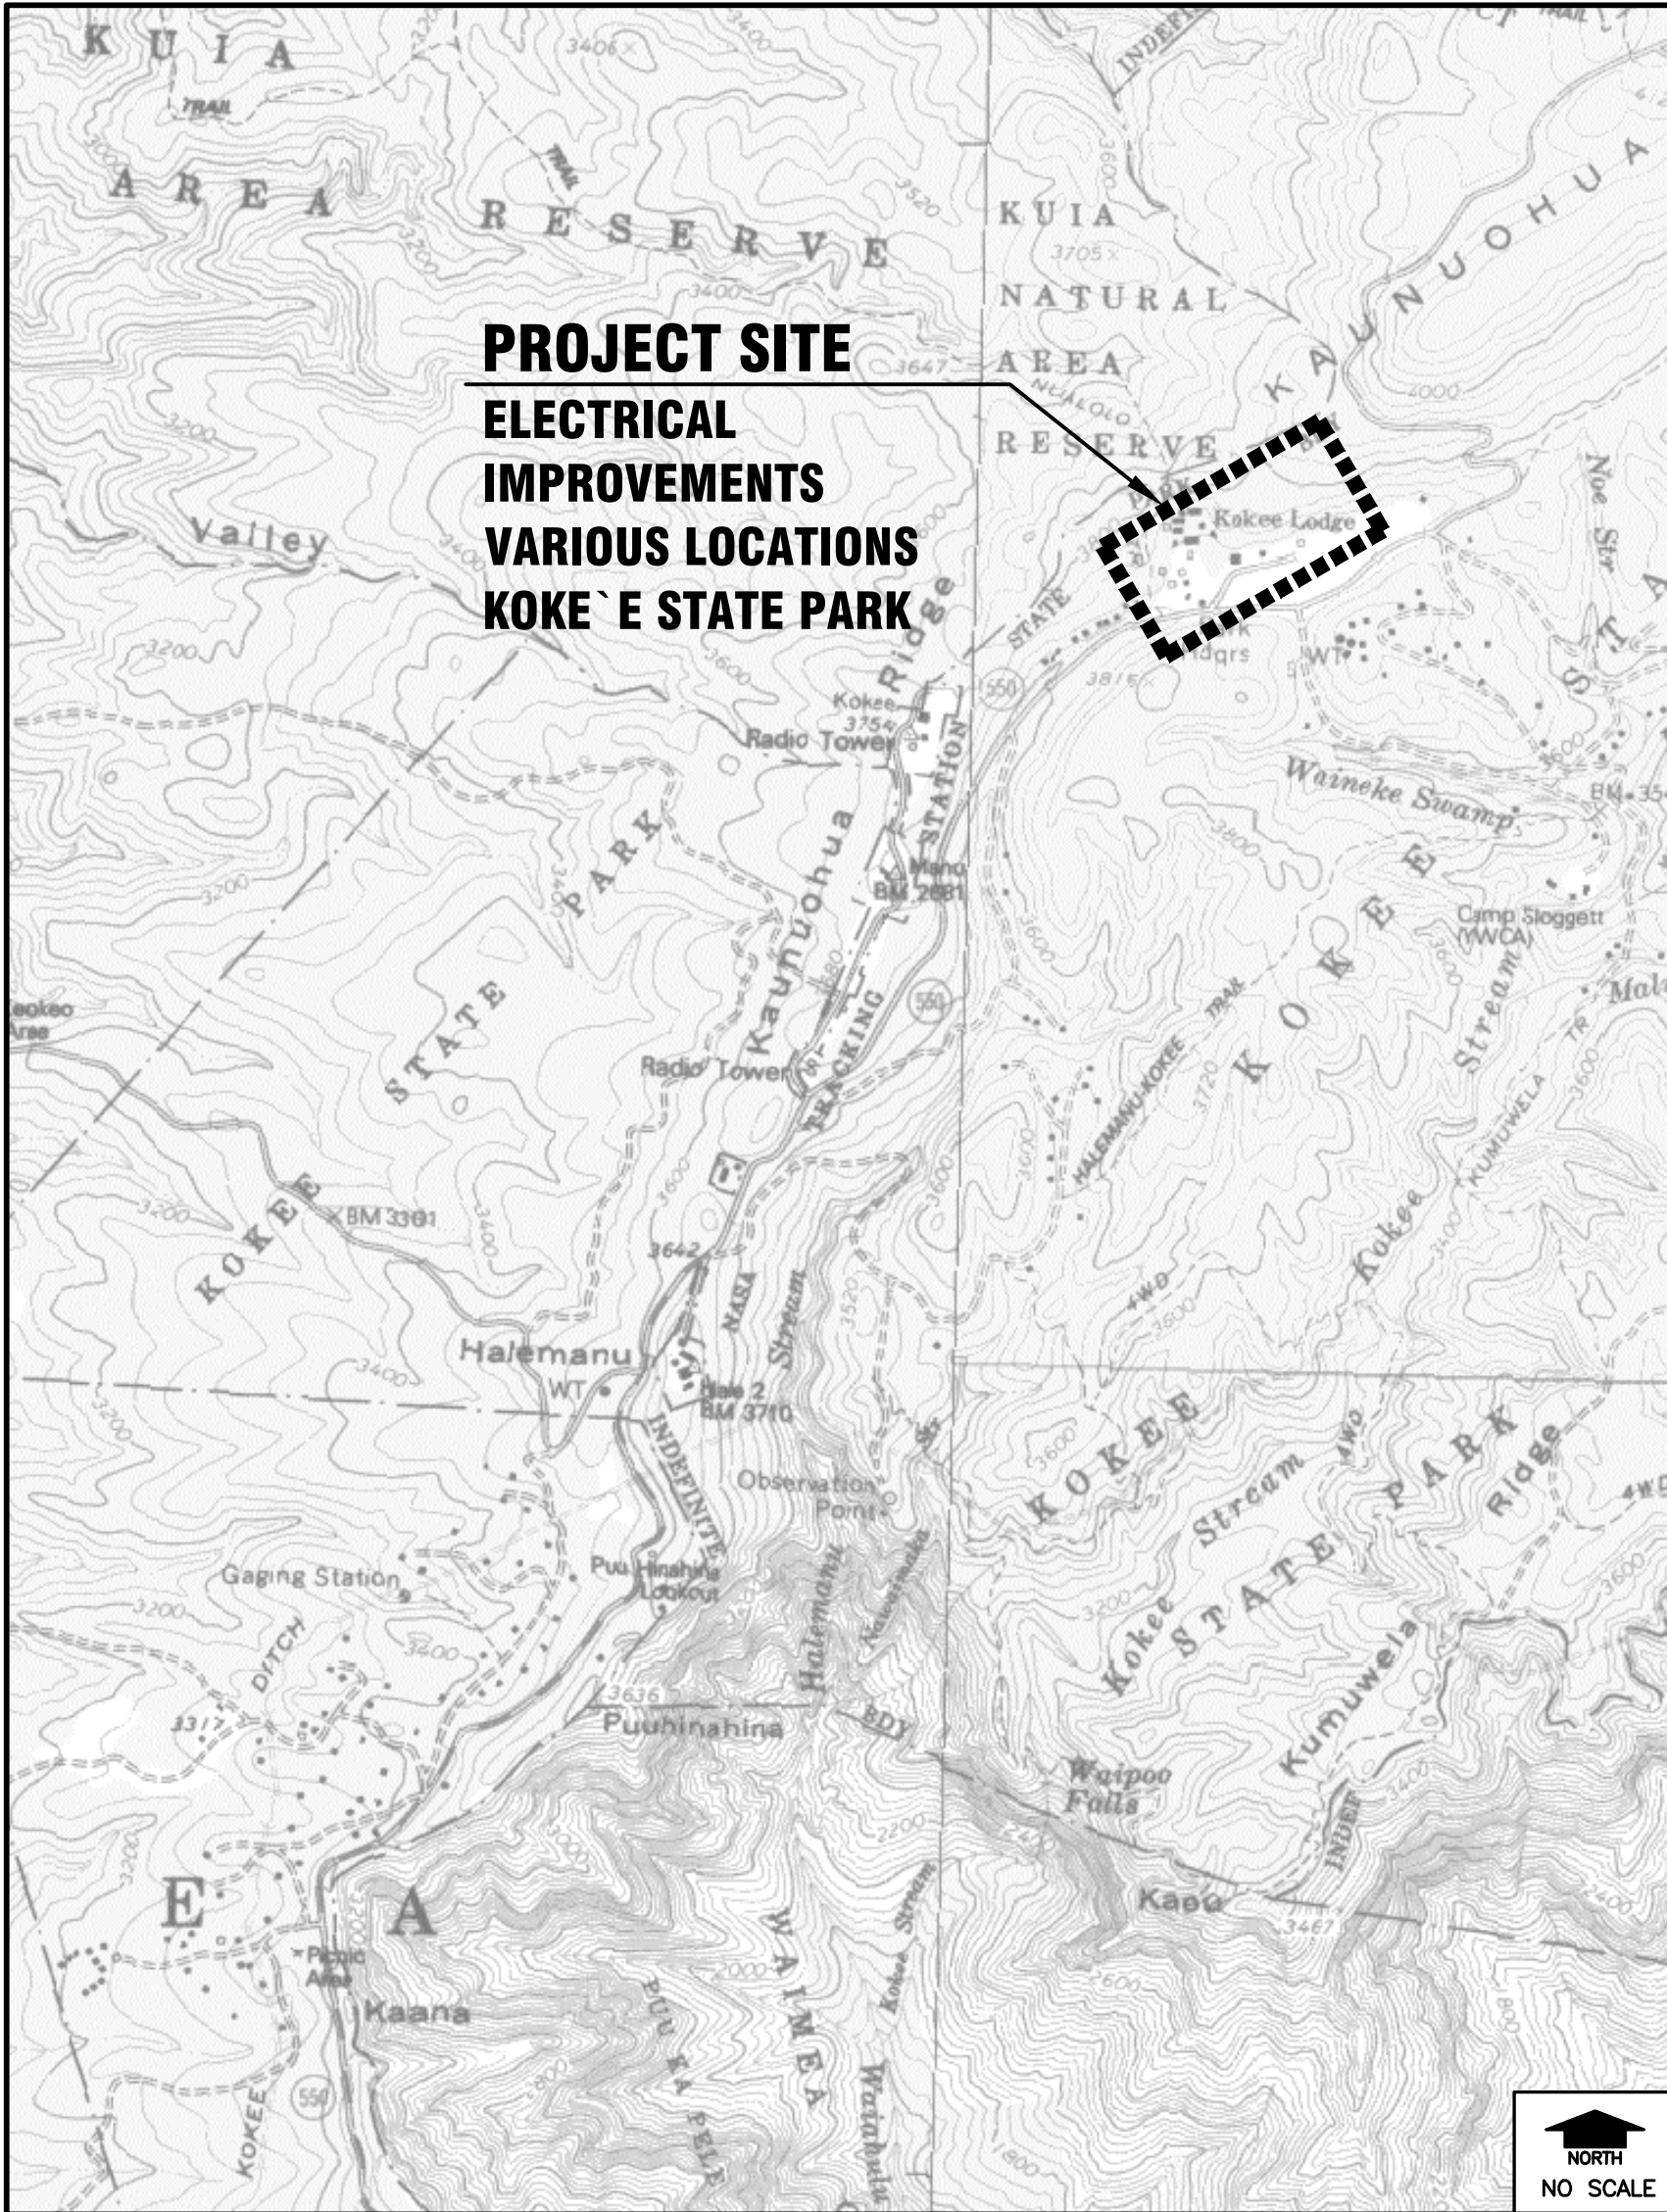

INDEX

DESCRIPTION	DRAWING NO.	SHEET NO.
TITLE SHEET	T-001	1
CONSTRUCTION NOTES - 1	G-001	2
CONSTRUCTION NOTES - 2	G-002	3
ELECTRICAL SYMBOLS, ABBREV, AND NOTES	E-001	4
STUDY OVERALL SITE PLAN	E-101	5
ELECTRICAL DEMO PLAN A (GARAGES AND STORAGE)	E-102	6
ELECTRICAL DEMO PLAN B (WORKSHOP AND RANGER'S COTTAGE)	E-103	7
ELECTRICAL DEMO PLAN C (PARK HEADQUARTERS)	E-104	8
ELECTRICAL PLAN A (GARAGES AND STORAGE)	E-105	9
ELECTRICAL PLAN B (WORKSHOP AND RANGER'S COTTAGE)	E-106	10
ELECTRICAL PLAN C (PARK HEADQUARTERS)	E-107	11
METERING ELEVATIONS - 1	E-201	12
METERING ELEVATIONS - 2	E-202	13
RANGER'S COTTAGE ELEVATIONS	E-203	14
PARK HEADQUARTERS ELEVATIONS	E-204	15
EXTERIOR ELECTRICAL DETAILS	E-501	16
ONE-LINE DIAGRAM - (METERS A, B AND C) - DEMO	E-601	17
ONE-LINE DIAGRAM - PARK HEADQUARTERS	E-602	18
ONE-LINE DIAGRAM - MAINT SHED-SHED-KOKEE LODGE STORAGE - DEMO	E-603	19
ONE-LINE DIAGRAM - MAINT SHED-SHED-KOKEE LODGE STORAGE	E-604	20
PANEL SCHEDULES	E-701	21

APPROVED: DATE: 05/07/2026

Alan B. Carpenter

ALAN B. CARPENTER
ACTING ADMINISTRATOR
DIVISION OF STATE PARKS
DEPARTMENT OF LAND AND NATURAL RESOURCES

APPROVED: DATE: 05/07/2026

Dina U. Lau

DINA U. LAU, P.E.
ACTING CHIEF ENGINEER
ENGINEERING DIVISION
DEPARTMENT OF LAND AND NATURAL RESOURCES

DRAWING NO.
T-001

- ALL CONSTRUCTION WORK IS TO BE CONSTRUCTED IN ACCORDANCE WITH THE ATTACHED SPECIFICATIONS AND PUBLICATIONS "HAWAII STANDARD SPECIFICATIONS FOR ROAD AND BRIDGE CONSTRUCTION, 2005" AND "STANDARD DETAILS FOR PUBLIC WORKS CONSTRUCTION DATED 9/84" WHEN REFERENCED.
2. NO WORK SHALL BE DONE ON SATURDAYS, SUNDAYS AND HOLIDAYS, AND/OR IN EXCESS OF EIGHT (8) HOURS EACH DAY WITHOUT THE WRITTEN CONSENT OF THE ENGINEER. NO WORK SHALL BE DONE AT NIGHT UNLESS AUTHORIZED BY THE ENGINEER.
3. THE CONTRACTOR SHALL VERIFY AND CHECK ALL DIMENSIONS AND DETAILS ON THE CONSTRUCTION DRAWINGS AND SPECIFICATIONS FOR ANY DISCREPANCY. ANY DISCREPANCY SHALL BE BROUGHT TO THE ATTENTION OF THE ENGINEER FOR CLARIFICATION.
4. WORK INCIDENTAL TO THE CONTRACT AND NECESSARY TO COMPLETE THE PROJECT, ALTHOUGH NOT SPECIFICALLY REFERRED TO ON THE CONTRACT DOCUMENTS, SHALL BE FURNISHED AND PERFORMED BY THE CONTRACTOR.
5. IN PERFORMING ALL WORK, THE CONTRACTOR SHALL EXERCISE DUE CARE AND CAUTION NECESSARY TO AVOID ANY DAMAGE TO AND IMPAIRMENT IN THE USE OF ANY EXISTING UTILITY LINE. ANY DAMAGE INFLICTED ON EXISTING UTILITY LINES RESULTING FROM THE CONTRACTOR'S OPERATIONS SHALL BE IMMEDIATELY REPAIRED OR RESTORED AS DIRECTED BY THE ENGINEER AT THE CONTRACTOR'S EXPENSE.
6. THE CONTRACTOR AGREES THAT HE SHALL ASSUME SOLE AND COMPLETE RESPONSIBILITY FOR THE JOB SITE CONDITIONS DURING THE COURSE OF CONSTRUCTION OF THIS PROJECT, INCLUDING THE SAFETY OF ALL PERSONS AND PROPERTY; THAT THIS REQUIREMENT SHALL APPLY CONTINUOUSLY AND NOT BE LIMITED TO NORMAL WORKING HOURS AND THAT THE CONTRACTOR SHALL DEFEND, INDEMNIFY AND HOLD THE OWNER AND ENGINEER HARMLESS FROM ANY AND ALL LIABILITY, REAL OR ALLEGED, IN CONNECTION WITH THE PERFORMANCE OF WORK ON THIS PROJECT, EXCEPTING FOR LIABILITY ARISING FROM THE SOLE NEGLIGENCE OF THE OWNER OR ENGINEER.
7. THE UNDERGROUND PIPES, CABLES OR DUCTLINES KNOWN TO EXIST BY THE ENGINEER FROM HIS SEARCH OF RECORDS ARE INDICATED ON THE PLANS. LOCATION OF EXISTING UTILITY LINES SHOWN ON THE PLAN AND PROFILE ARE APPROXIMATE. THEREFORE, NO ASSURANCE CAN BE PROVIDED THAT THE ACTUAL LOCATIONS WILL BE PRECISELY AS SHOWN ON THE CONTRACT DRAWINGS. THE CONTRACTOR SHALL VERIFY THE LOCATION AND DEPTH OF THE FACILITIES PRIOR TO EXCAVATING IN THE AREA AND EXERCISE PROPER CARE WHILE EXCAVATING. WHEREVER CONNECTIONS OF NEW UTILITIES TO EXISTING UTILITIES ARE SHOWN ON THE PLANS, THE CONTRACTOR SHALL EXPOSE THE EXISTING LINES AT THE PROPOSED CONNECTIONS TO VERIFY THEIR LOCATIONS AND CONNECTING CONDITIONS.
8. ADEQUATE PROVISIONS FOR TRAFFIC CONTROL SHALL BE PROVIDED IN ACCORDANCE WITH "HAWAII ADMINISTRATIVE RULES GOVERNING THE USE OF TRAFFIC CONTROL DEVICES AT WORK SITES ON OR ADJACENT TO PUBLIC STREETS AND HIGHWAYS OF HAWAII" AND WITH FEDERAL HIGHWAY ADMINISTRATION "MANUAL ON UNIFORM TRAFFIC CONTROL DEVICES FOR STREETS AND HIGHWAYS", 2003 WITH THE LATEST REVISIONS, AND TO THE SATISFACTION OF THE ENGINEER.
9. THE CONTRACTOR SHALL CONDUCT ALL TESTS AS SPECIFIED AND BE RESPONSIBLE FOR EXPENSES INCURRED IN CONDUCTING THESE TESTS.
10. CONTRACTOR SHALL MAKE ARRANGEMENTS FOR UTILITIES SUCH AS ELECTRICITY, WATER, ETC., REQUIRED FOR HIS OPERATIONS AND ALL COSTS SHALL BE BORNE BY THE CONTRACTOR.
11. THE CONTRACTOR SHALL PROVIDE TO THE ENGINEER RECORD DRAWINGS OF ALL UTILITIES AND STRUCTURES UPON COMPLETION OF WORK. A PROFILE ALONG THE CENTERLINE SHALL ALSO BE PROVIDED TO VERIFY THE FINISHED GRADES OF ROADWAYS.
12. WRITTEN DIMENSIONS TAKE PRECEDENCE OVER SCALED DIMENSIONS.
13. ALL PERMITS SHALL BE OBTAINED AND PAID FOR BY THE CONTRACTOR, UNLESS OTHERWISE INDICATED.
14. THE CONTRACTOR SHALL COORDINATE THE STORAGE OF HIS MATERIAL WITH THE ENGINEER.
15. ALL CONSTRUCTION AND GRADING STAKEOUT SHALL BE DONE BY A SURVEYOR REGISTERED IN THE STATE OF HAWAII. CONTRACTOR SHALL SUBMIT COPIES OF THE STAKEOUT DOCUMENTATION INCLUDING CUT SHEETS, AND ALL COSTS SHALL BE BORNE BY THE CONTRACTOR.
16. THE CONTRACTOR SHALL OBSERVE AND COMPLY WITH ALL FEDERAL, STATE, AND LOCAL LAWS REQUIRED FOR THE PROTECTION OF PUBLIC HEALTH, SAFETY, AND ENVIRONMENTAL QUALITY.
17. THE CONTRACTOR SHALL BE REQUIRED TO PROVIDE ADEQUATE, SAFE NON-SKID BRIDGING MATERIAL OVER TRENCHES, INCLUDING SHORING WHEN TRENCHING IN PAVEMENT AREAS AND AREAS SUBJECT TO VEHICULAR TRAFFIC TO HANDLE ALL TYPES OF VEHICULAR TRAFFIC. NO TRENCH SHALL BE LEFT OPEN DURING NON-WORKING HOURS, STRIKES, OR JOB SHUTDOWN.
18. THE CONTRACTOR SHALL REMOVE ALL SILT AND DEBRIS RESULTING FROM HIS WORK. ANY NECESSARY REMEDIAL ACTION AS REQUIRED BY THE STATE OR COUNTY ENGINEER SHALL BE DONE BY THE CONTRACTOR AT HIS OWN EXPENSE.
19. CONSTRUCTION DEBRIS AND WASTE SHALL BE DEPOSITED AT AN APPROPRIATE SITE IN ACCORDANCE WITH ALL COUNTY, STATE AND FEDERAL LAWS, RULES AND REGULATIONS. THE CONTRACTOR SHALL INFORM THE ENGINEER OF THE LOCATION OF THE DISPOSAL SITE.

20. GRADING AROUND ALL STRUCTURES, CONCRETE PADS AND PIPE RESTS, UNLESS OTHERWISE SHOWN OR INDICATED, SHALL BE MINIMUM 1" ABOVE THE SURROUNDING GRADE AT THE EDGE OF CONCRETE. GRADE SHALL SLOPE AWAY FROM THE EDGE OF CONCRETE AT MAX. 1" PER FOOT TO MEET EXISTING GRADE. PROVISIONS FOR DRAINAGE AROUND STRUCTURES SHALL BE PROVIDED.
21. ALL GRADING OPERATIONS SHALL CONFORM WITH APPLICABLE PROVISIONS OF THE WATER POLLUTION CONTROL AND WATER QUALITY STANDARDS CONTAINED IN THE PUBLIC HEALTH REGULATIONS, STATE DEPARTMENT OF HEALTH.
22. ALL SLOPES, SWALES, AND EXPOSED AREAS SHALL BE SEEDED OR PLANTED AS SOON AS PRACTICABLE AFTER THE WORK HAS BEEN COMPLETED.
23. DLNR WILL DELEGATE THE CONTRACTOR AS THE AUTHORIZED REPRESENTATIVE TO SUBMIT ALL NECESSARY DOCUMENTS AND REPORTS AS REQUIRED BY DOH AND COUNTY OF KAUAI DIRECTLY TO THEIR OFFICES AT NO COSTS TO THE STATE.
24. CONTRACTOR SHALL REMOVE ALL THE TREES WITHIN THE ALIGNMENT OF THE WATER LINES AT NO EXTRA COST TO THE STATE.

1. MEASURES TO CONTROL EROSION AND OTHER POLLUTANTS SHALL BE IN PLACE BEFORE ANY CONSTRUCTION WORK IS INITIATED. THESE MEASURES SHALL BE PROPERLY CONSTRUCTED AND MAINTAINED THROUGHOUT THE CONSTRUCTION PERIODS.
2. ALL CONTROL MEASURES SHALL BE CHECKED AND REPAIRED AS NECESSARY.
3. CONSTRUCT TEMPORARY SILT FENCE AS SHOWN PER PLANS.
4. ALL STORM DRAIN INLETS THAT MAY RECEIVE RUNOFF AS A RESULT OF THE CONSTRUCTION WORK SHALL USE AN INLET FILTER DEVICE. INLET FILTERS SHALL REMAIN UNTIL COMPLETION OF CONSTRUCTION WORK. CONTRACTOR SHALL PERIODICALLY INSPECT INLET FILTERS, ESPECIALLY DURING HEAVY RAINFALL, TO ENSURE DRAINAGE THROUGH MATERIAL IS MAINTAINED.
5. AT THE END OF THE GRADING OPERATION, EXISTING STORM DRAIN INLETS SURROUNDING THE PROJECT SITE SHALL BE INSPECTED AND ANY ACCUMULATED SEDIMENT AND DEBRIS FOUND IN THE STORM DRAIN INLETS SHALL BE REMOVED. FLUSHING INTO THE STORM DRAINS IS PROHIBITED.
6. GOOD HOUSEKEEPING SHALL BE UTILIZED TO ENSURE PROTECTION OF ROADWAYS FROM MUD, DIRT, AND DEBRIS.
7. THE CONTRACTOR SHALL ENSURE THAT ALL TIRES OF CONSTRUCTION VEHICLES ARE SUFFICIENTLY CLEANED OFF SO THE DIRT OR DEBRIS IS NOT TRACKED OFF THE CONSTRUCTION SITE. WASHING OFF TIRES WITH WATER WILL NOT BE ACCEPTABLE UNLESS THE RUNOFF IS CONTAINED AND DOES NOT ENTER THE STORM DRAIN SYSTEM OR ONTO THE STATE'S ROW.
8. THE CONTRACTOR SHALL ENSURE THAT EXISTING ROADWAYS USED TO ACCESS THE PROJECT ARE CLEANED OF ALL DEBRIS, TRASH, DIRT, MUD, ETC., THROUGHOUT THE WORK DAY.
9. THE FINAL LIFT OF EACH DAY'S WORK SHALL BE COMPACTED TO PREVENT EROSION OF FILL MATERIAL.
10. ANY DIRT OR GRASSED AREA DISTURBED SHALL BE RESTORED BY SEEDED HYDRO-MULCH. CONTRACTOR TO ENSURE GRASS IS FULLY ESTABLISHED.
11. THE GRASS MAINTENANCE PERIOD SHALL BE SIXTY (60) CALENDAR DAYS OR UNTIL ACCEPTANCE OF ALL ITEMS OF WORK UNDER THIS CONTRACT, WHICHEVER IS LATER.

1. IN THE UNLIKELY EVENT THAT SUBSURFACE HISTORIC RESOURCES, SUCH AS HUMAN SKELETAL REMAINS, STRUCTURAL REMAINS, CULTURAL DEPOSITS, ARTIFACTS, SAND DEPOSITS, OR SINK HOLDS ARE DISCOVERED DURING DEMOLITION AND/OR CONSTRUCTION WORK, THE WORK SHOULD BE STOPPED IN THE IMMEDIATE AREA OF THE DISCOVERY. THE FIND SHOULD BE PROTECTED FROM FURTHER DISTURBANCE, AND THE STATE HISTORIC PRESERVATION DIVISION SHOULD BE CONTACTED AT (808) 692-8015.

REVISION NO.	SYM	DESCRIPTION	SHT./OF	DATE	APPROVED
 This work was prepared by me or under my supervision and construction of this project will be under my observation. Observation of construction as defined by Hawaii Administrative Rules, Title 16, Dept. of Commerce & Consumer Affairs, Chapter 115, Professional Engineers, Architects, Surveyors and Landscapers. <i>(Signature)</i> FUKUNAGA & ASSOCIATES, INC. License Expiration Date: April 30, 2028			STATE OF HAWAII DEPARTMENT OF LAND AND NATURAL RESOURCES ENGINEERING DIVISION		
			KOKE'E STATE PARK ELECTRICAL IMPROVEMENTS WAIMEA, KAUAI, HAWAII		
			CONSTRUCTION NOTES - 1		
			FUKUNAGA AND ASSOCIATES, INC		
			DESIGNED: AA	SUBMITTED:	
DRAWN: JT	DATE: APRIL 2026				
CHECKED: JTM 	SCALE: AS SHOWN				
APPROVED: Dina Lau E-signed 2026-05-07 07:15AM HST dina.u.lau@hawaii.gov			DRAWING NO. G-001		
CHIEF ENGINEER					

ELECTRICAL SYMBOLS

	LED STRIP FIXTURE, SURFACE CEILING MOUNTED
	LIGHT FIXTURE, CEILING MOUNTED
	PANELBOARD
	DUPLEX RECEPTACLE WITH GFCI PROTECTION, NEMA 5-20R, 125V, +18" AFF UON
	LARGE JUNCTION BOX, SIZE AS INDICATED
	LARGE JUNCTION BOX, WALL MOUNTED, SIZE AS INDICATED
	SMALL JUNCTION (OUTLET) BOX
	SMALL JUNCTION (OUTLET) BOX, WALL MOUNTED
	LARGE JUNCTION BOX, WALL MOUNTED, SIZE AS INDICATED
	ENCLOSED CIRCUIT BREAKER, +5'-6" TO TOP UON
	SINGLE POLE SWITCH, 20A, 120/277V - 3=3 WAY, 4=4 WAY, D=DIMMER
	WEATHERPROOF
	UNLESS OTHERWISE NOTED
	CONDUIT UP
	CONDUIT DOWN
	CONDUIT & WIRING IN WALL OR CEILING
	CONDUIT & WIRING BELOW REFERENCED PLANE
	CONDUIT & WIRING EXPOSED
	HOMERUN TO APPLICABLE PANEL
	CONDUIT STUB
	FLEXIBLE CONDUIT
	TYPE NM WIRING

MINIMUM CONDUIT SIZE SHALL BE 3/4". ANY CIRCUIT WITH NO FURTHER DESIGNATION INDICATES A TWO (2) WIRE CIRCUIT. CIRCUITS WITH ADDITIONAL WIRES ARE INDICATED AS FOLLOWS: 3 WIRES, 4 WIRES, ETC. MINIMUM CONDUCTOR SIZE MUST BE #12. ALTHOUGH NOT INDICATED A SEPARATE GREEN GROUND CONDUCTOR SIZED PER THE N.E.C. SHALL BE INSTALLED IN ALL BRANCH CIRCUIT CONDUITS.


ONE-LINE SYMBOLS

	PANELBOARD
	MOLDED CASE CIRCUIT BREAKER
	SAFETY SWITCH - NON FUSED
	TRANSFORMER
	WATT-HOUR METER
	SURGE PROTECTIVE DEVICE
	GROUND CONNECTION

SITE ELECTRICAL SYMBOLS

	EXISTING WOOD POLE
	GUY ANCHOR
	UNDERGROUND DUCTLINE
	DUCT SECTION INDICATOR

DUCT DESIGNATION

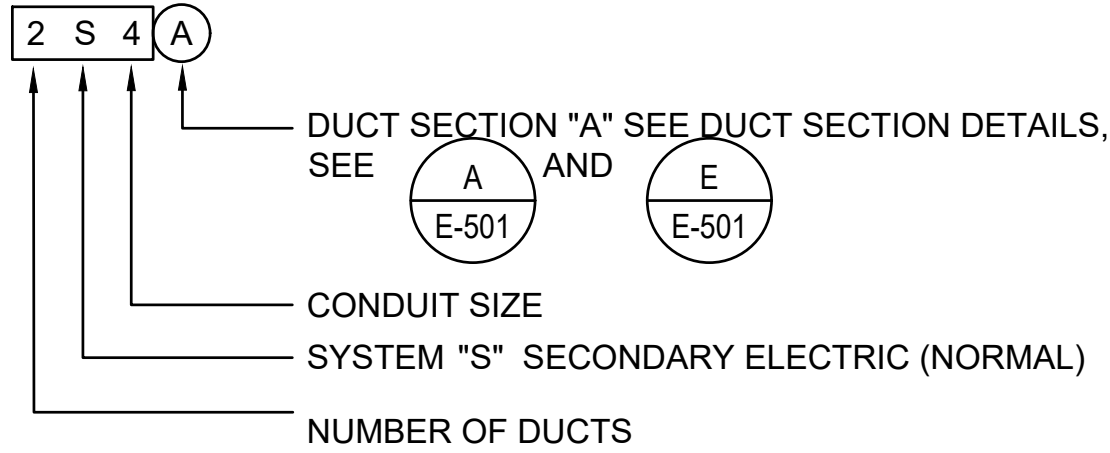

GENERAL NOTES:

- THE DRAWINGS DO NOT REFLECT ALL THE EXISTING CONDITIONS THAT MAY BE ENCOUNTERED DURING CONSTRUCTION. VISIT THE PROJECT SITE AND BECOME FAMILIAR WITH THE EXISTING CONDITIONS, THE EXTENT OF ANY DEMOLITION WORK, AND THE NEW WORK PRIOR TO THE START OF ON-SITE CONSTRUCTION ACTIVITIES. REPORT ANY DISCREPANCIES AND/OR DIFFERENCES BETWEEN THE EXISTING CONDITIONS AND THE CONSTRUCTION DOCUMENTS TO THE CONTRACTING OFFICER PRIOR TO COMMENCING CONSTRUCTION. RESOLVE ALL DISCREPANCIES AND QUESTIONS PRIOR TO THE START OF WORK.
- EXISTING DEVICE LOCATIONS, CIRCUIT ASSIGNMENTS, WIRING CONNECTIONS, AND CONDUIT RUNS INDICATED WERE DERIVED FROM LIMITED FIELD INVESTIGATION. FIELD VERIFY ALL EXISTING CONDITIONS AND MAKE ANY NECESSARY ADJUSTMENTS TO SATISFY THE INTENT OF THE DRAWINGS AND SPECIFICATIONS.
- OBTAIN ALL STANDARDS AND DRAWINGS RELATED TO THIS PROJECT FROM THE UTILITY COMPANIES. VERIFY THAT THE UTILITY COMPANY'S PROJECT DRAWINGS ARE THE SAME AS THE CONTRACT DRAWINGS. NOTIFY THE ENGINEER OF ANY DIFFERENCES BETWEEN THEM. IF DIFFERENCES EXIST, OBTAIN A RESOLUTION PRIOR TO PROCEEDING WITH THE WORK WHICH IS AFFECTED.
- VERIFY AND CHECK ALL DIMENSIONS AND DETAILS ON THE CONSTRUCTION DRAWINGS AND SPECIFICATIONS FOR ANY DISCREPANCY. ANY DISCREPANCY MUST BE BROUGHT TO THE ATTENTION OF THE CONTRACTING OFFICER FOR CLARIFICATION.
- WORK INCIDENTAL TO THE CONTRACT AND NECESSARY TO COMPLETE THE PROJECT, ALTHOUGH NOT SPECIFICALLY REFERRED TO ON THE CONTRACT DOCUMENTS, MUST BE FURNISHED AND PERFORMED BY THE CONTRACTOR.
- THE UNDERGROUND PIPES, CABLES OR DUCTLINES KNOWN TO EXIST BY THE ENGINEER FROM HIS SEARCH OF RECORDS ARE INDICATED ON THE PLANS. LOCATION OF EXISTING UTILITY LINES SHOWN ON THE PLANS ARE APPROXIMATE. THEREFORE, NO ASSURANCE CAN BE PROVIDED THAT THE ACTUAL LOCATIONS WILL BE PRECISELY AS SHOWN ON THE CONTRACT DOCUMENTS. THE CONTRACTOR MUST VERIFY THE LOCATION AND DEPTH OF THE UTILITIES AND EXERCISE PROPER CARE IN EXCAVATING IN THE AREA. WHEREVER CONNECTIONS OF NEW UTILITIES TO EXISTING UTILITIES ARE SHOWN ON THE PLANS, THE CONTRACTOR MUST EXPOSE THE EXISTING LINES AT THE PROPOSED CONNECTIONS TO VERIFY THEIR LOCATIONS.
- THE DEMOLITION DRAWINGS ARE INTENDED TO SHOW THE GENERAL LIMITS OF THE WORK AND DO NOT SHOW ALL THE EXISTING APPARATUS, DEVICES, LIGHT FIXTURES, EQUIPMENT CONNECTIONS, CONDUIT RUNS, ETC. DISCONNECT AND REMOVE THE ELECTRICAL APPARATUS, DEVICES, LIGHT FIXTURES, ETC. AND CONDUIT AND WIRING BACK TO ITS SOURCE. EXISTING CONCEALED WIRING TO BE REMOVED MUST BE DISCONNECTED FROM ITS SOURCE. CONDUITS EMERGING OUT OF THE FLOOR MUST BE CUT FLUSH WITH FLOOR AND HAVE THEIR OPENINGS SEALED.
- REMOVAL OF EXISTING ELECTRICAL DISTRIBUTION SYSTEM: REMOVAL OF EXISTING ELECTRICAL DISTRIBUTION SYSTEM EQUIPMENT MUST INCLUDE EQUIPMENT'S ASSOCIATED WIRING INCLUDING CONDUCTORS, CABLES, EXPOSED CONDUIT, SURFACE METAL RACEWAYS, BOXES, FITTINGS, ETC. BACK TO EQUIPMENT'S SOURCE. UNDERGROUND CONDUITS/DUCTS NO LONGER NEEDED MAY BE ABANDONED IN PLACE.
- RE-ROUTE ALL EXISTING CONDUIT, WIRING AND CABLING TO REMAIN WITHIN THE PROJECT AREA AS NECESSARY TO FACILITATE THE REMOVAL OF EXISTING EQUIPMENT AS WELL AS THE INSTALLATION OF ALL NEW EQUIPMENT.
- THE LOCATION OF ALL ELECTRICAL APPARATUS AND DEVICES ARE APPROXIMATE AND BEFORE INSTALLING, STUDY THE ARCHITECTURAL, STRUCTURAL, AND MECHANICAL DETAILS AND MAKE INSTALLATION IN THE MOST LOGICAL MANNER. ANY PIECE OF EQUIPMENT/DEVICE MAY BE RELOCATED WITHIN 10' BEFORE INSTALLATION AT THE DIRECTION OF THE ENGINEER WITHOUT ADDITIONAL CHARGE TO THE OWNER.

- ALL OPENINGS RESULTING FROM REMOVAL WORK AND NOT REUSED MUST BE SEALED.
- ALL DISCONNECT SWITCHES MUST HAVE THE PANELBOARD AND CIRCUIT NUMBER IDENTIFIED ON THE ENCLOSURE. PROVIDE POLYESTER TYPE LABELS THAT ARE RESISTANT TO MOISTURE, EXTREME TEMPERATURES, CHEMICALS, FADING, AND UV LIGHT. LETTERS MUST NOT BE LESS THAN 0.75" HIGH.
- DO NOT INSTALL DISSIMILAR METALS IN DIRECT CONTACT WITH EACH OTHER TO PREVENT GALVANIC CORROSION. PROVIDE APPROPRIATE BARRIERS.
- PAINTING OF ELECTRICAL EQUIPMENT:
 - INTERIOR LOCATIONS - PRIME AND PAINT ALL EXPOSED CONDUITS, BOXES, FITTINGS, SUPPORT CHANNELS, MOUNTING HARDWARE AND ACCESSORIES WITH TWO FINISH COATS TO MATCH THE SURFACE ON WHICH THEY ARE MOUNTED OR TO MATCH THE FINISH OF THE ADJACENT SURFACES. EQUIPMENT SURFACES/COMPONENTS WITH A FACTORY-APPLIED PAINT FINISH NEED NOT BE PAINTED.
 - EXTERIOR LOCATIONS - PRIME ALL EXPOSED CONDUITS, BOXES, FITTINGS, SUPPORT CHANNELS, MOUNTING HARDWARE AND ACCESSORIES WITH A 2-PART EPOXY PRIMER AND FINISH WITH 2 COATS OF AN ALIPHATIC ACRYLIC URETHANE PAINT. PAINT FINISH TO MATCH THE SURFACE ON WHICH THEY ARE MOUNTED OR TO MATCH THE FINISH OF THE ADJACENT SURFACES. STAINLESS STEEL MATERIALS NEED NOT BE PAINTED.
- THE CONTRACTOR MUST PROVIDE ADEQUATE, NON-SKID BRIDGING MATERIAL OVER TRENCHES, INCLUDING SHORING WHEN TRENCHING IN PAVEMENT AREAS TO HANDLE ALL TYPES OF VEHICULAR AND PEDESTRIAN TRAFFIC. NO TRENCH MUST BE LEFT OPEN DURING NON-WORKING HOURS OR JOB SHUTDOWN.
- ALL EXTERIOR EQUIPMENT: JUNCTION BOXES AND DISCONNECT SWITCHES, MUST BE STAINLESS STEEL, NEMA 4X.
- THE CONDUIT LOCATIONS INDICATED ARE SCHEMATIC. RELOCATE JUNCTION BOXES AS NECESSARY TO FACILITATE THE CONDUIT INSTALLATION AT NO ADDITIONAL COST TO THE GOVERNMENT. JUNCTION BOXES MUST REMAIN ACCESSIBLE PER NFPA 70.
- ELECTRICAL APPARATUS AND INSTALLATION MUST BE SUITABLE FOR THE SEISMIC CATEGORY FOR THE ISLAND PER THE BUILDING CODE.
- ALL PENETRATIONS THROUGH EXTERIOR WALLS AND ROOFS MUST BE SEALED WEATHER-TIGHT WITH UL APPROVED MATERIALS AND METHODS AND IN ACCORDANCE WITH THE IBC.
- ALL CONDUITS ENTERING PANELS FROM THE EXTERIOR MUST BE VAPOR SEALED/DUCT SEALED TO PREVENT WATER VAPOR AND MOISTURE FROM MIGRATING INTO PANELS.
- SEAL ALL CONDUITS ENTERING JUNCTION BOXES, ENCLOSURES, PANELBOARDS, SWITCHBOARDS, ETC. TO PREVENT INSECTS/PESTS FROM MIGRATING THROUGH THE ELECTRICAL DISTRIBUTION SYSTEM.
- ALL RECEPTACLES, SWITCHES, AND DISCONNECT SWITCHES MUST HAVE THE PANELBOARD AND CIRCUIT NUMBER IDENTIFIED ON THE DEVICE PLATE. PROVIDE INDUSTRIAL ADHESIVE VINYL OR POLYESTER TYPE LABELS THAT ARE RESISTANT TO MOISTURE, EXTREME TEMPERATURES, CHEMICALS, AND UV LIGHT ON THE DEVICE PLATE. LETTERS MUST BE NOT LESS THAN 1/4" HIGH. PRESSURE SENSITIVE OR THERMAL TAPES NOT ALLOWED.
- EXPOSED EXTERIOR CONDUITS SHALL BE PVC COATED GALVANIZED RIDIG STEEL, STAINLESS STEEL, OR FIBERGLASS WITH A PROTECTIVE UV COATING.
- THE CONTRACTOR, AT THEIR EXPENSE, MUST RESTORE TO THE ORIGINAL CONDITION OR BETTER ALL EXISTING FACILITIES TO REMAIN THAT ARE DAMAGED AS A RESULT OF CONSTRUCTION.
- REPAIR AND PAINT ALL SURFACES DAMAGED BY NEW CONSTRUCTION OR EXPOSED/DAMAGED DUE TO REMOVAL OF EXISTING EQUIPMENT. COLOR TO MATCH ADJACENT SURFACES.
- CONTRACTOR MUST TONE AREA PRIOR TO DIGGING. ANY DAMAGE TO EXISTING UNDERGROUND UTILITIES TO REMAIN RESULTING FROM FAILURE TO DO SO MUST BE REPAIRED BY THE CONTRACTOR AT NO ADDITIONAL COST TO THE PROJECT.
- THE CONTRACTOR SHALL VISIT THE PROJECT SITE AND FAMILIARIZE HIMSELF/HERSELF WITH ALL EXISTING CONDITIONS AND THE EXTENT OF THE REMOVAL, RECONNECTION, AND NEW WORK PRIOR TO BIDDING. BID SUBMISSION SHALL BE CONSIDERED AS EVIDENCE THAT THE CONTRACTOR HAS VISITED THE SITE AND RESOLVED ALL DISCREPANCIES AND QUESTIONS AND NO EXTRA PAYMENT WILL BE AUTHORIZED FOR WORK REQUIRED BY THE CONTRACTOR'S FAILURE TO DO SO.
- THE CONTRACTOR MUST REGRASS AND LANDSCAPE ALL UNPAVED AREAS DISTURBED BY CONSTRUCTION ACTIVITIES. AREAS MUST BE RESTORED WITH GRASS SEEDING, SPRIGS OR TURF. THE GRASS MUST BE PLANTED, FERTILIZED, WATERED AND MAINTAINED BY THE CONTRACTOR FOR 90 DAYS OR UNTIL THE GRASS IS FULLY ESTABLISHED.


ABBREVIATIONS

&	AND		
@	AT		
#	NUMBER		
+	PLUS		
A,AMPS	AMPERES		
ABV	ABOVE		
AC	ALTERNATING CURRENT		
ADD'TL	ADDITIONAL		
ADJ	ADJACENT		
AFF	ABOVE FINISHED FLOOR	KCMIL	KILO CIRCULAR MILS
AFG	ABOVE FINISHED GRADE	KIUC	KAUAI ISLAND UTILITY COOPERATIVE
AIC	AMPERES INTERRUPTING CAPACITY	KV	KILO-VOLTS
BKR	BREAKER	KVA	KILO-VOLT-AMPERE
BLDG	BUILDING	KW	KILOWATT
C	CONDUIT	L	LENGTH
CB	CIRCUIT BREAKER	LTG	LIGHTING
CKT	CIRCUIT	MIN	MINIMUM
CKTS	CIRCUITS	MISC	MISCELLANEOUS
CLG	CEILING	MT	MOUNT
DISC	DISCONNECT	MTD	MOUNTED
DN	DOWN	MTG	MOUNTING
DP	DEEP	NEC	NATIONAL ELECTRICAL CODE
DT	DRY-TYPE	NO.	NUMBER
DWG	DRAWING	N1	NEMA TYPE 1 ENCLOSURE
DWGS	DRAWINGS	N3R	NEMA TYPE 3R ENCLOSURE
		N4X	NEMA TYPE 4X ENCLOSURE
EA	EACH	PFB	PROVISION FOR FUTURE CIRCUIT BREAKER
ELEC	ELECTRICAL	PH	PHASE
ELEV	ELEVATION	PNL	PANEL
EMT	ELECTRICAL METALLIC TUBING	PVC	POLYVINYL CHLORIDE
ENCL	ENCLOSURE	SEC	SECONDARY
EQPT	EQUIPMENT	SQ	SQUARE
EQUIP	EQUIPMENT	SW	SWITCH
EXH	EXHAUST	TEMP	TEMPORARY
EXST	EXISTING	TYP	TYPICAL
EXIST	EXISTING	UON	UNLESS OTHERWISE NOTED
FDR	FEEDER	V	VOLT
FT	FOOT/FEET	VA	VOLT-AMPERE
G,GND	GROUND	W	WATT
GALV	GALVANIZED	W	WIDTH
GFCI	GROUND FAULT CIRCUIT INTERRUPTER	WP	WEATHER-PROOF
GRC	GALVANIZED RIDIG CONDUIT		
H	HEIGHT	XFMR	TRANSFORMER
IC	INTERRUPTING CAPACITY		
I.E.	THAT IS		
IN	INCH		
INFO	INFORMATION		
JB	JUNCTION BOX		

BRANCH CIRCUIT WIRING GENERAL NOTE:

- DO NOT USE A COMMON NEUTRAL FOR MULTI-WIRE BRANCH CIRCUITS. PROVIDE A DEDICATED NEUTRAL FOR EACH CIRCUIT.


REVISION NO.	SYM.	DESCRIPTION	SHT./OF	DATE	APPROVED
		STATE OF HAWAII DEPARTMENT OF LAND AND NATURAL RESOURCES ENGINEERING DIVISION KOKE'E STATE PARK ELECTRICAL IMPROVEMENTS WAIMEA, KAUAI, HAWAII			
ELECTRICAL SYMBOLS, ABBREV, AND NOTES					
FUKUNAGA AND ASSOCIATES, INC					
DESIGNED: ACH		SUBMITTED:			
DRAWN: MKE		DATE: APRIL 2026			
CHECKED: ACH		SCALE: AS SHOWN			
APPROVED: Dina Lau E-signed 2026-05-07 07:15AM HST dina.u.lau@hawaii.gov State of Hawaii		DRAWING NO. E-001			
CHIEF ENGIN		SHEET NO. 4 OF 21 SHEETS			


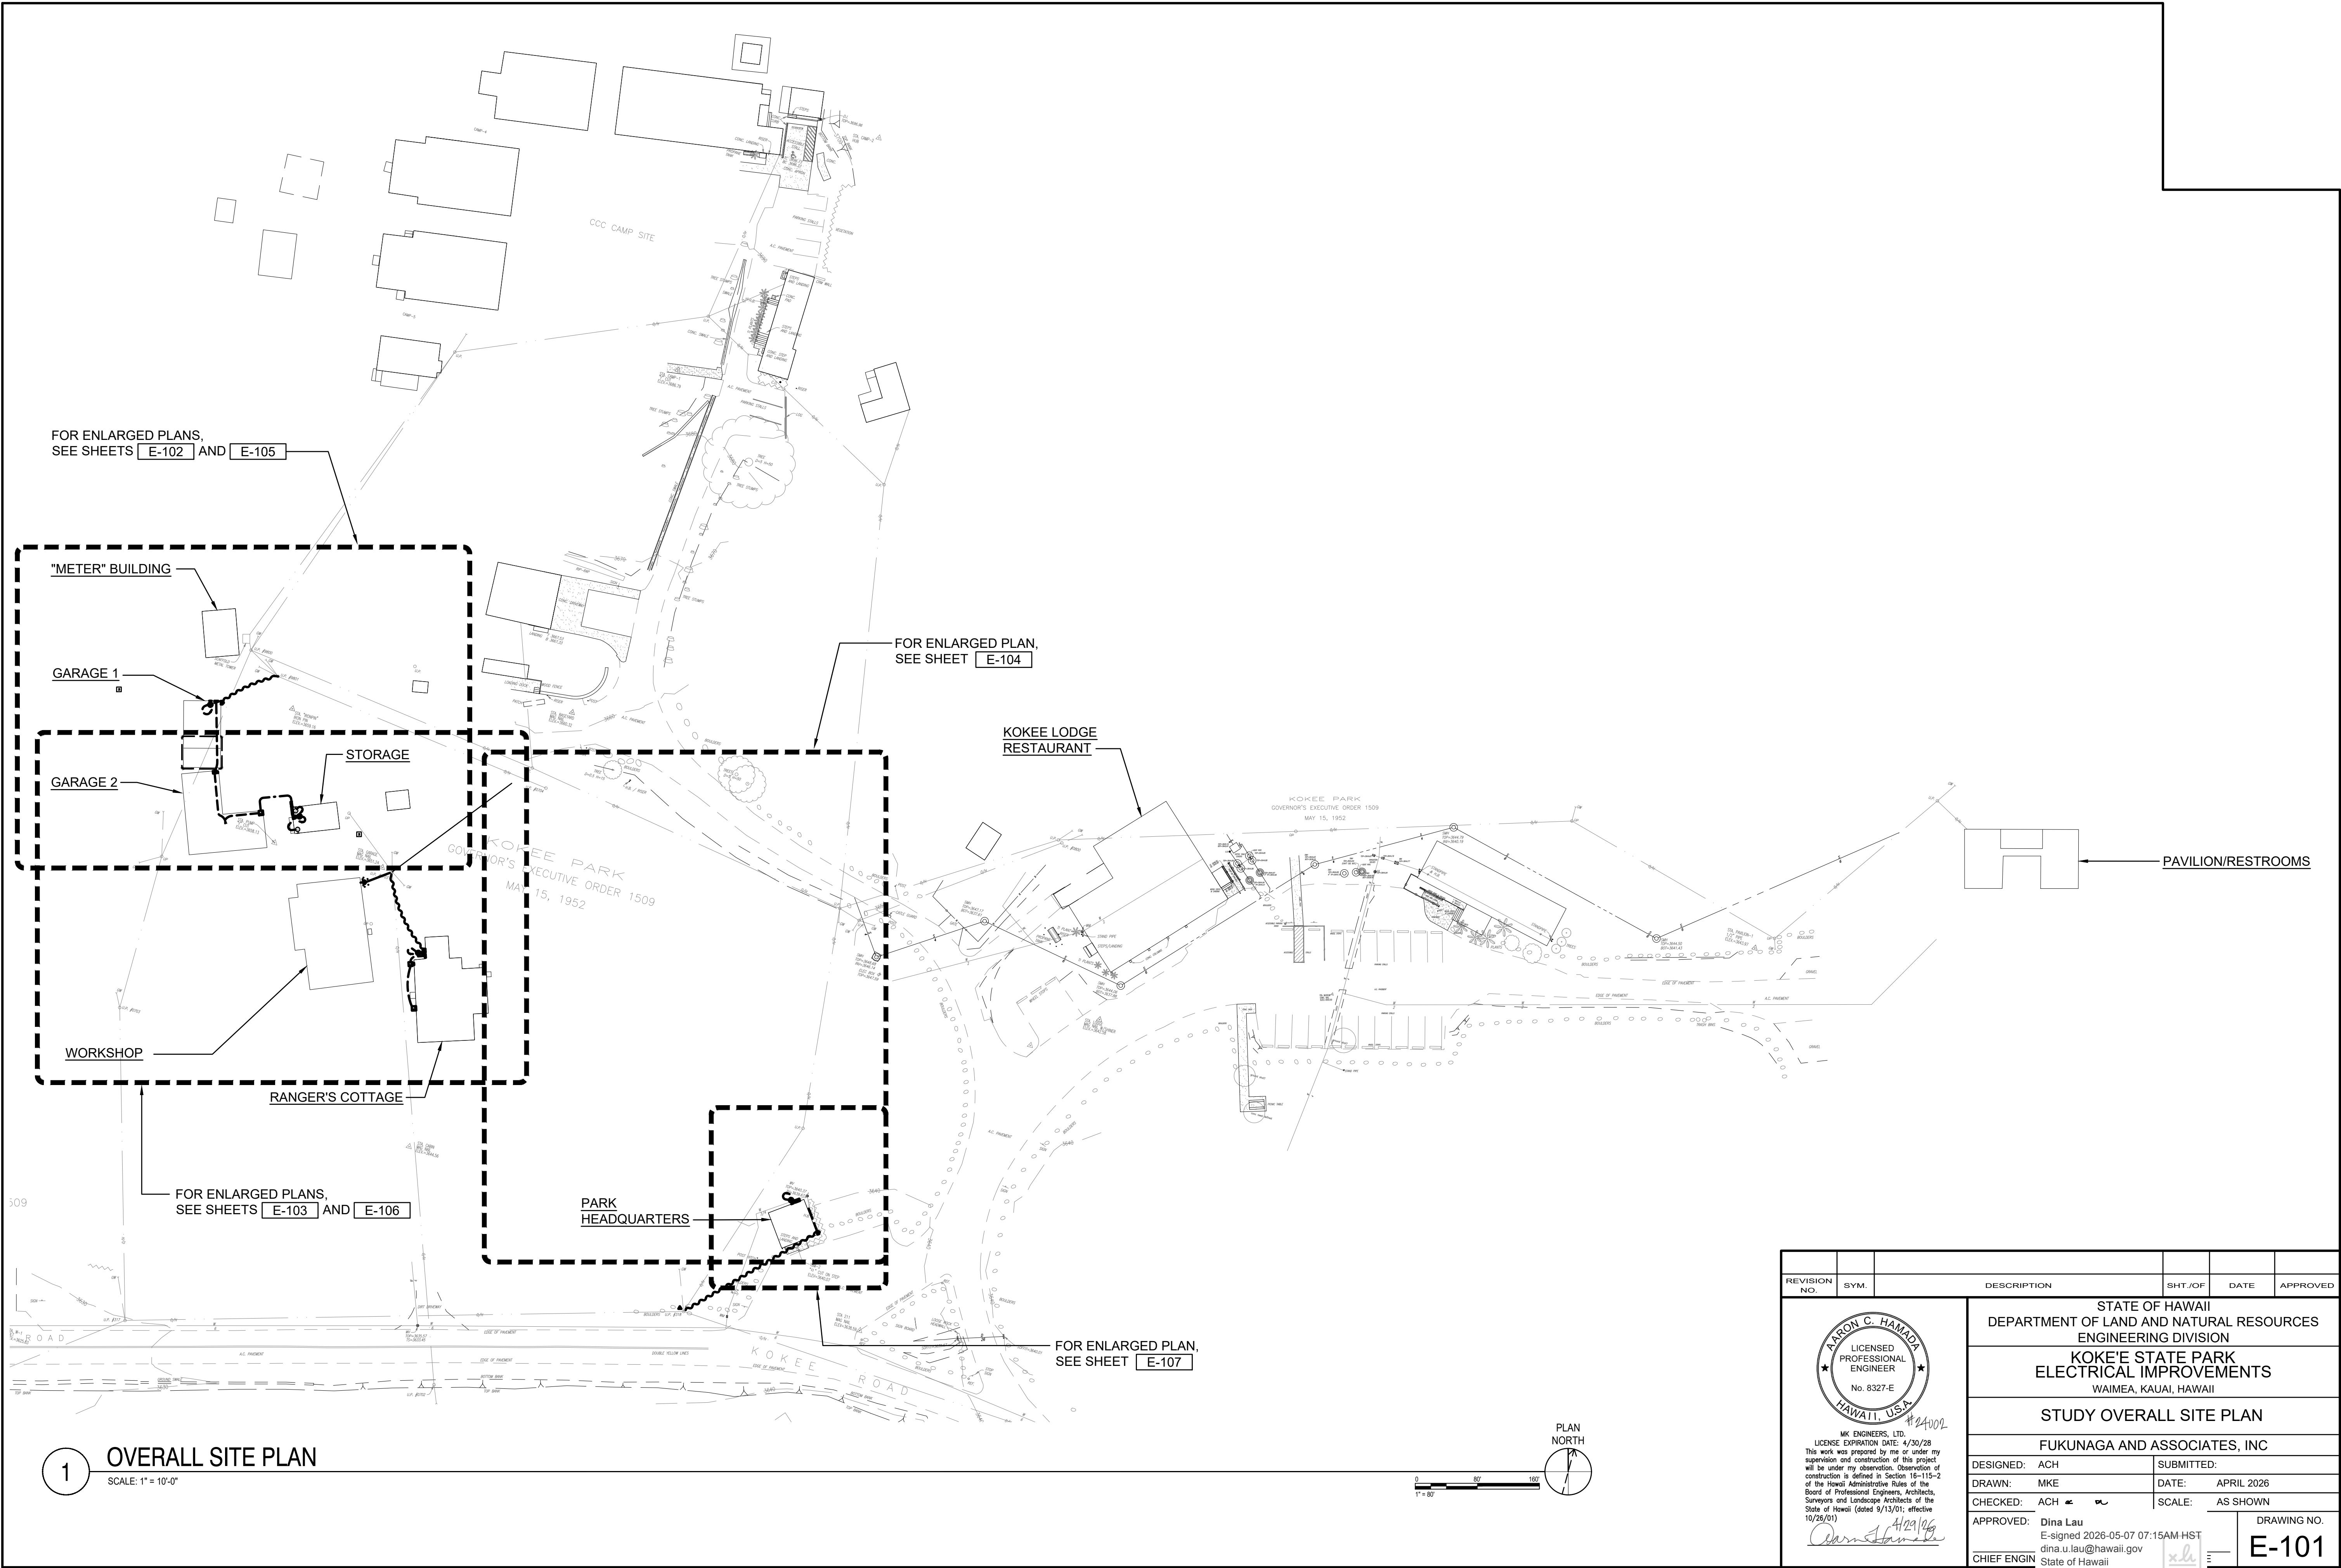


1 OVERALL SITE PLAN

SCALE: 1" = 10'-0"

REVISION NO.	SYM.	DESCRIPTION	SHT./OF	DATE	APPROVED
STATE OF HAWAII DEPARTMENT OF LAND AND NATURAL RESOURCES ENGINEERING DIVISION					
KOKE'E STATE PARK ELECTRICAL IMPROVEMENTS WAIMEA, KAUAI, HAWAII					
STUDY OVERALL SITE PLAN					
FUKUNAGA AND ASSOCIATES, INC.					
DESIGNED:	ACH	SUBMITTED:			
DRAWN:	MKE	DATE:	APRIL 2026		
CHECKED:	ACH	SCALE:	AS SHOWN		
APPROVED:	Dina Lau E-signed 2026-05-07 07:15AM HST dina.u.lau@hawaii.gov State of Hawaii		DRAWING NO. E-101		
CHIEF ENGINEER	Civil Engineer		SHEET NO. 5 OF 21 SHEETS		

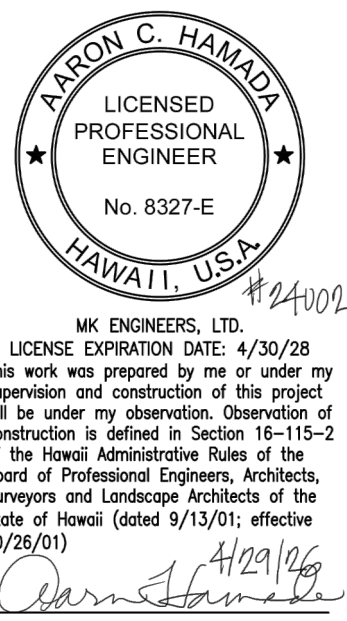

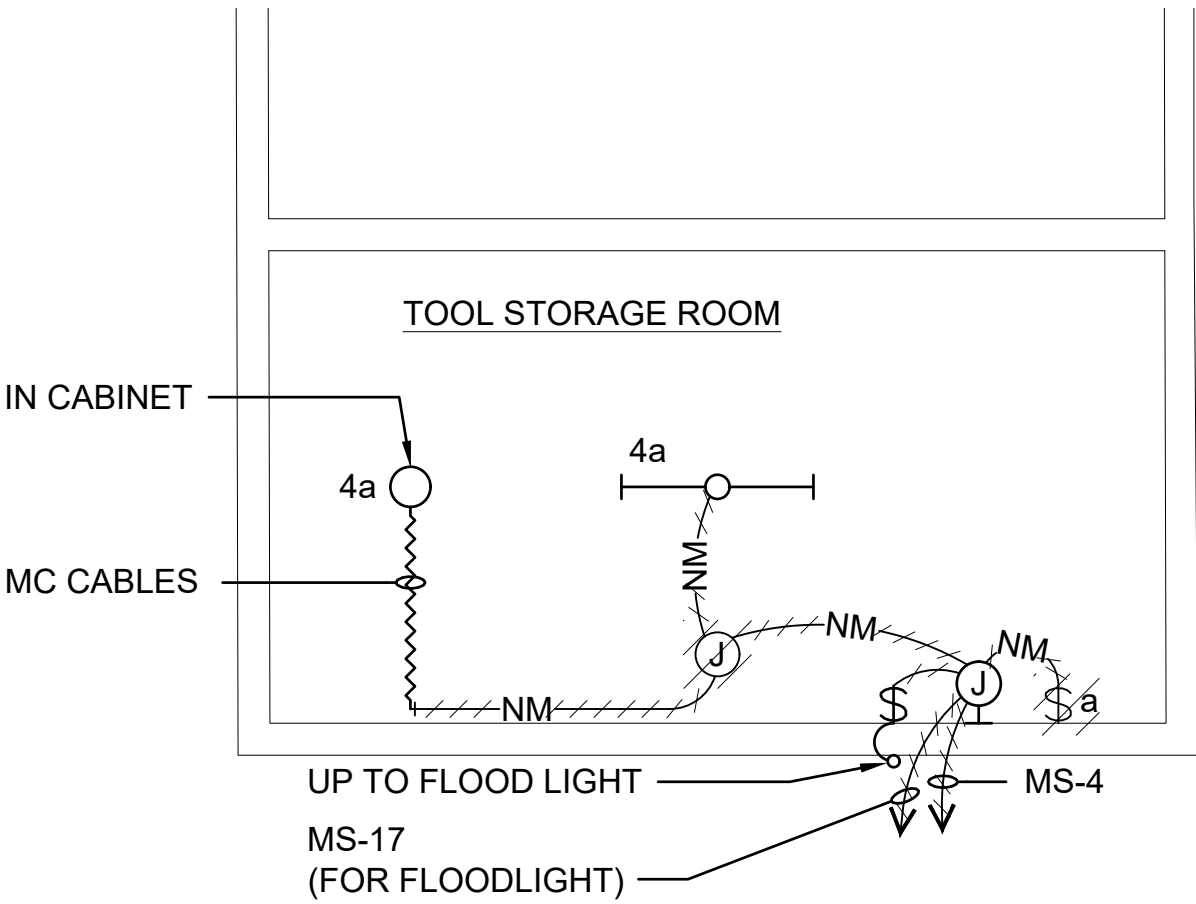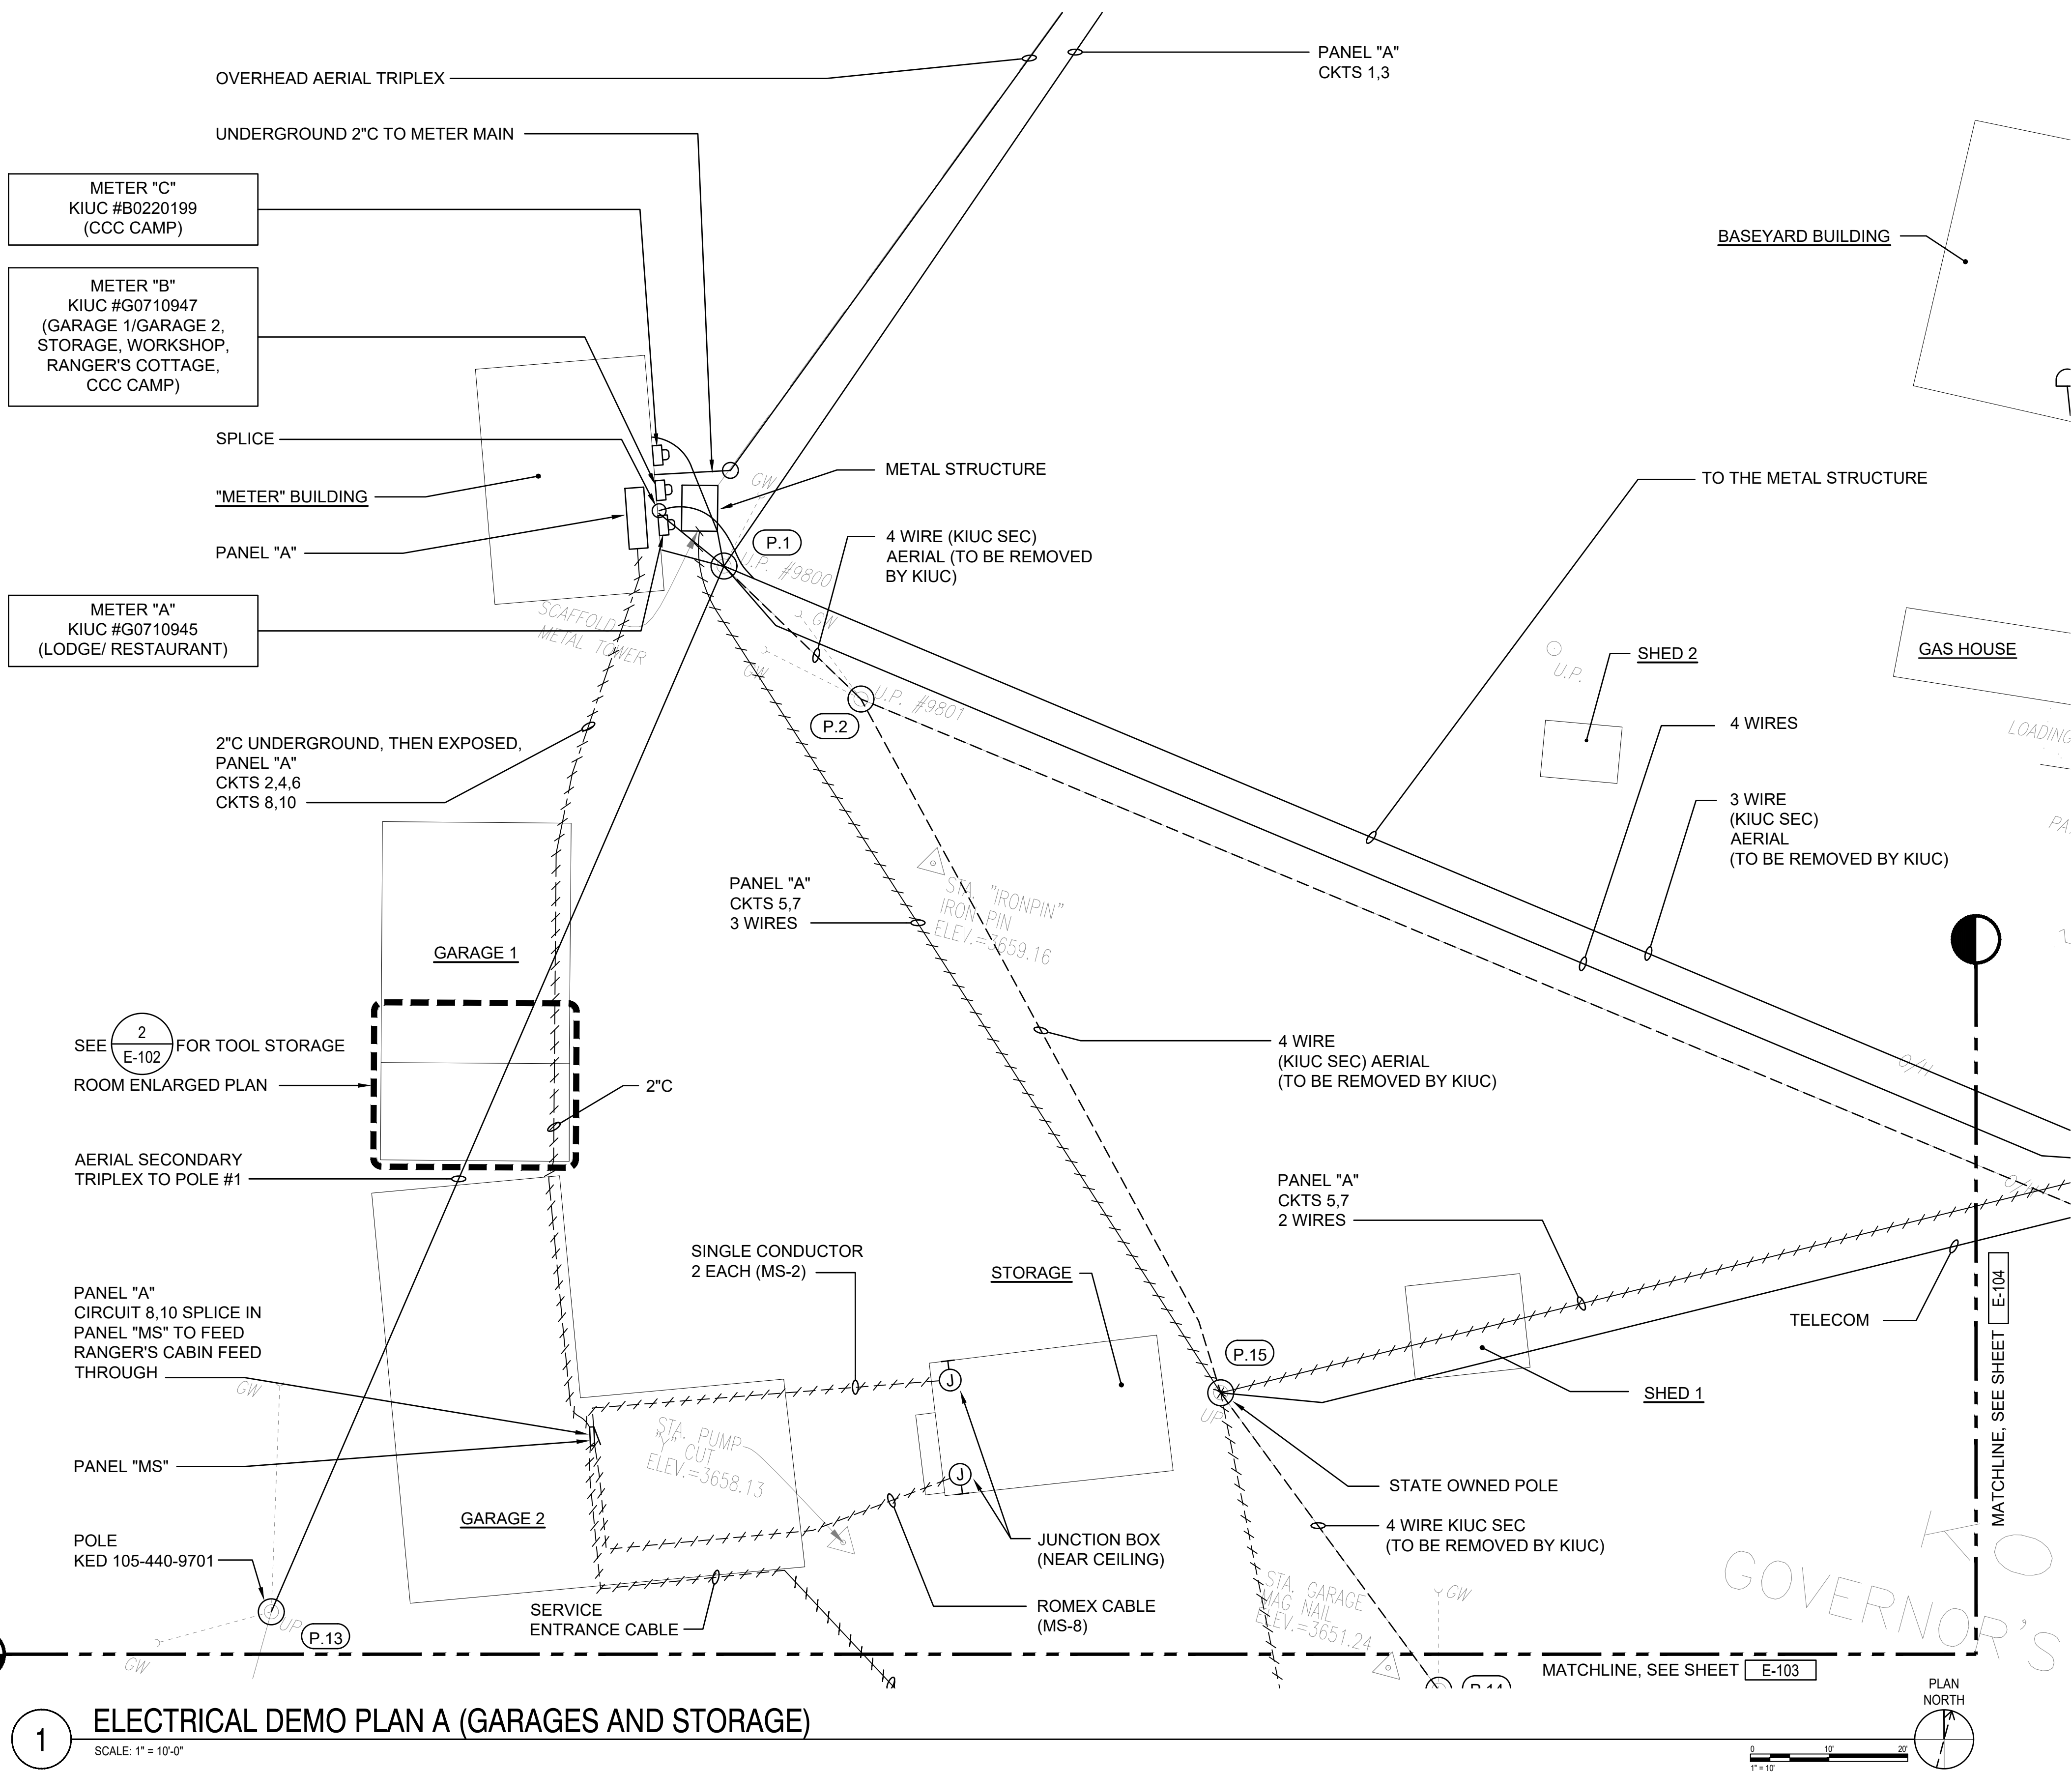

2 TOOL STORAGE ROOM ENLARGED DEMOLITION PLAN

SCALE: 1/4" = 1'-0"

PLAN NORTH

NOTES:

1. LIGHT LINES DENOTE EXISTING CONDITION

"I" DENOTES REMOVAL WORK

1 ELECTRICAL DEMO PLAN A (GARAGES AND STORAGE)

SCALE: 1" = 10'-0"

NOTES:

1. LIGHT LINES DENOTE EXISTING CONDITION


"I" DENOTES REMOVAL WORK

"R" DENOTES REMOVAL OF EXISTING CONDUCTORS FROM EXISTING CONDUIT. CONDUIT TO BE REUSED.

2 INTERCEPT EXISTING CONDUIT AND CONDUCTORS WITH NEW WIREWAY.

3. CONTRACTOR IS RESPONSIBLE FOR DISPOSAL OF ITEMS TO BE REMOVED. FOR UNDERGROUND/BURIED CONDUIT/DUCT, REMOVE CONDUCTORS AND ABANDON CONDUIT/DUCT IN PLACE.

REVISION NO.	SYM.	DESCRIPTION	SHT./OF	DATE	APPROVED
STATE OF HAWAII DEPARTMENT OF LAND AND NATURAL RESOURCES ENGINEERING DIVISION KOKE'E STATE PARK ELECTRICAL IMPROVEMENTS WAIMEA, KAUAI, HAWAII ELECTRICAL DEMO PLAN A (GARAGES AND STORAGE) FUKUNAGA AND ASSOCIATES, INC					
DESIGNED: ACH			SUBMITTED:		
DRAWN: MKE			DATE: APRIL 2026		
CHECKED: ACH			SCALE: AS SHOWN		
APPROVED: Dina Lau E-signed 2026-05-07 07:15AM HST dina.u.lau@hawaii.gov State of Hawaii Civil Engineer			DRAWING NO. E-102		

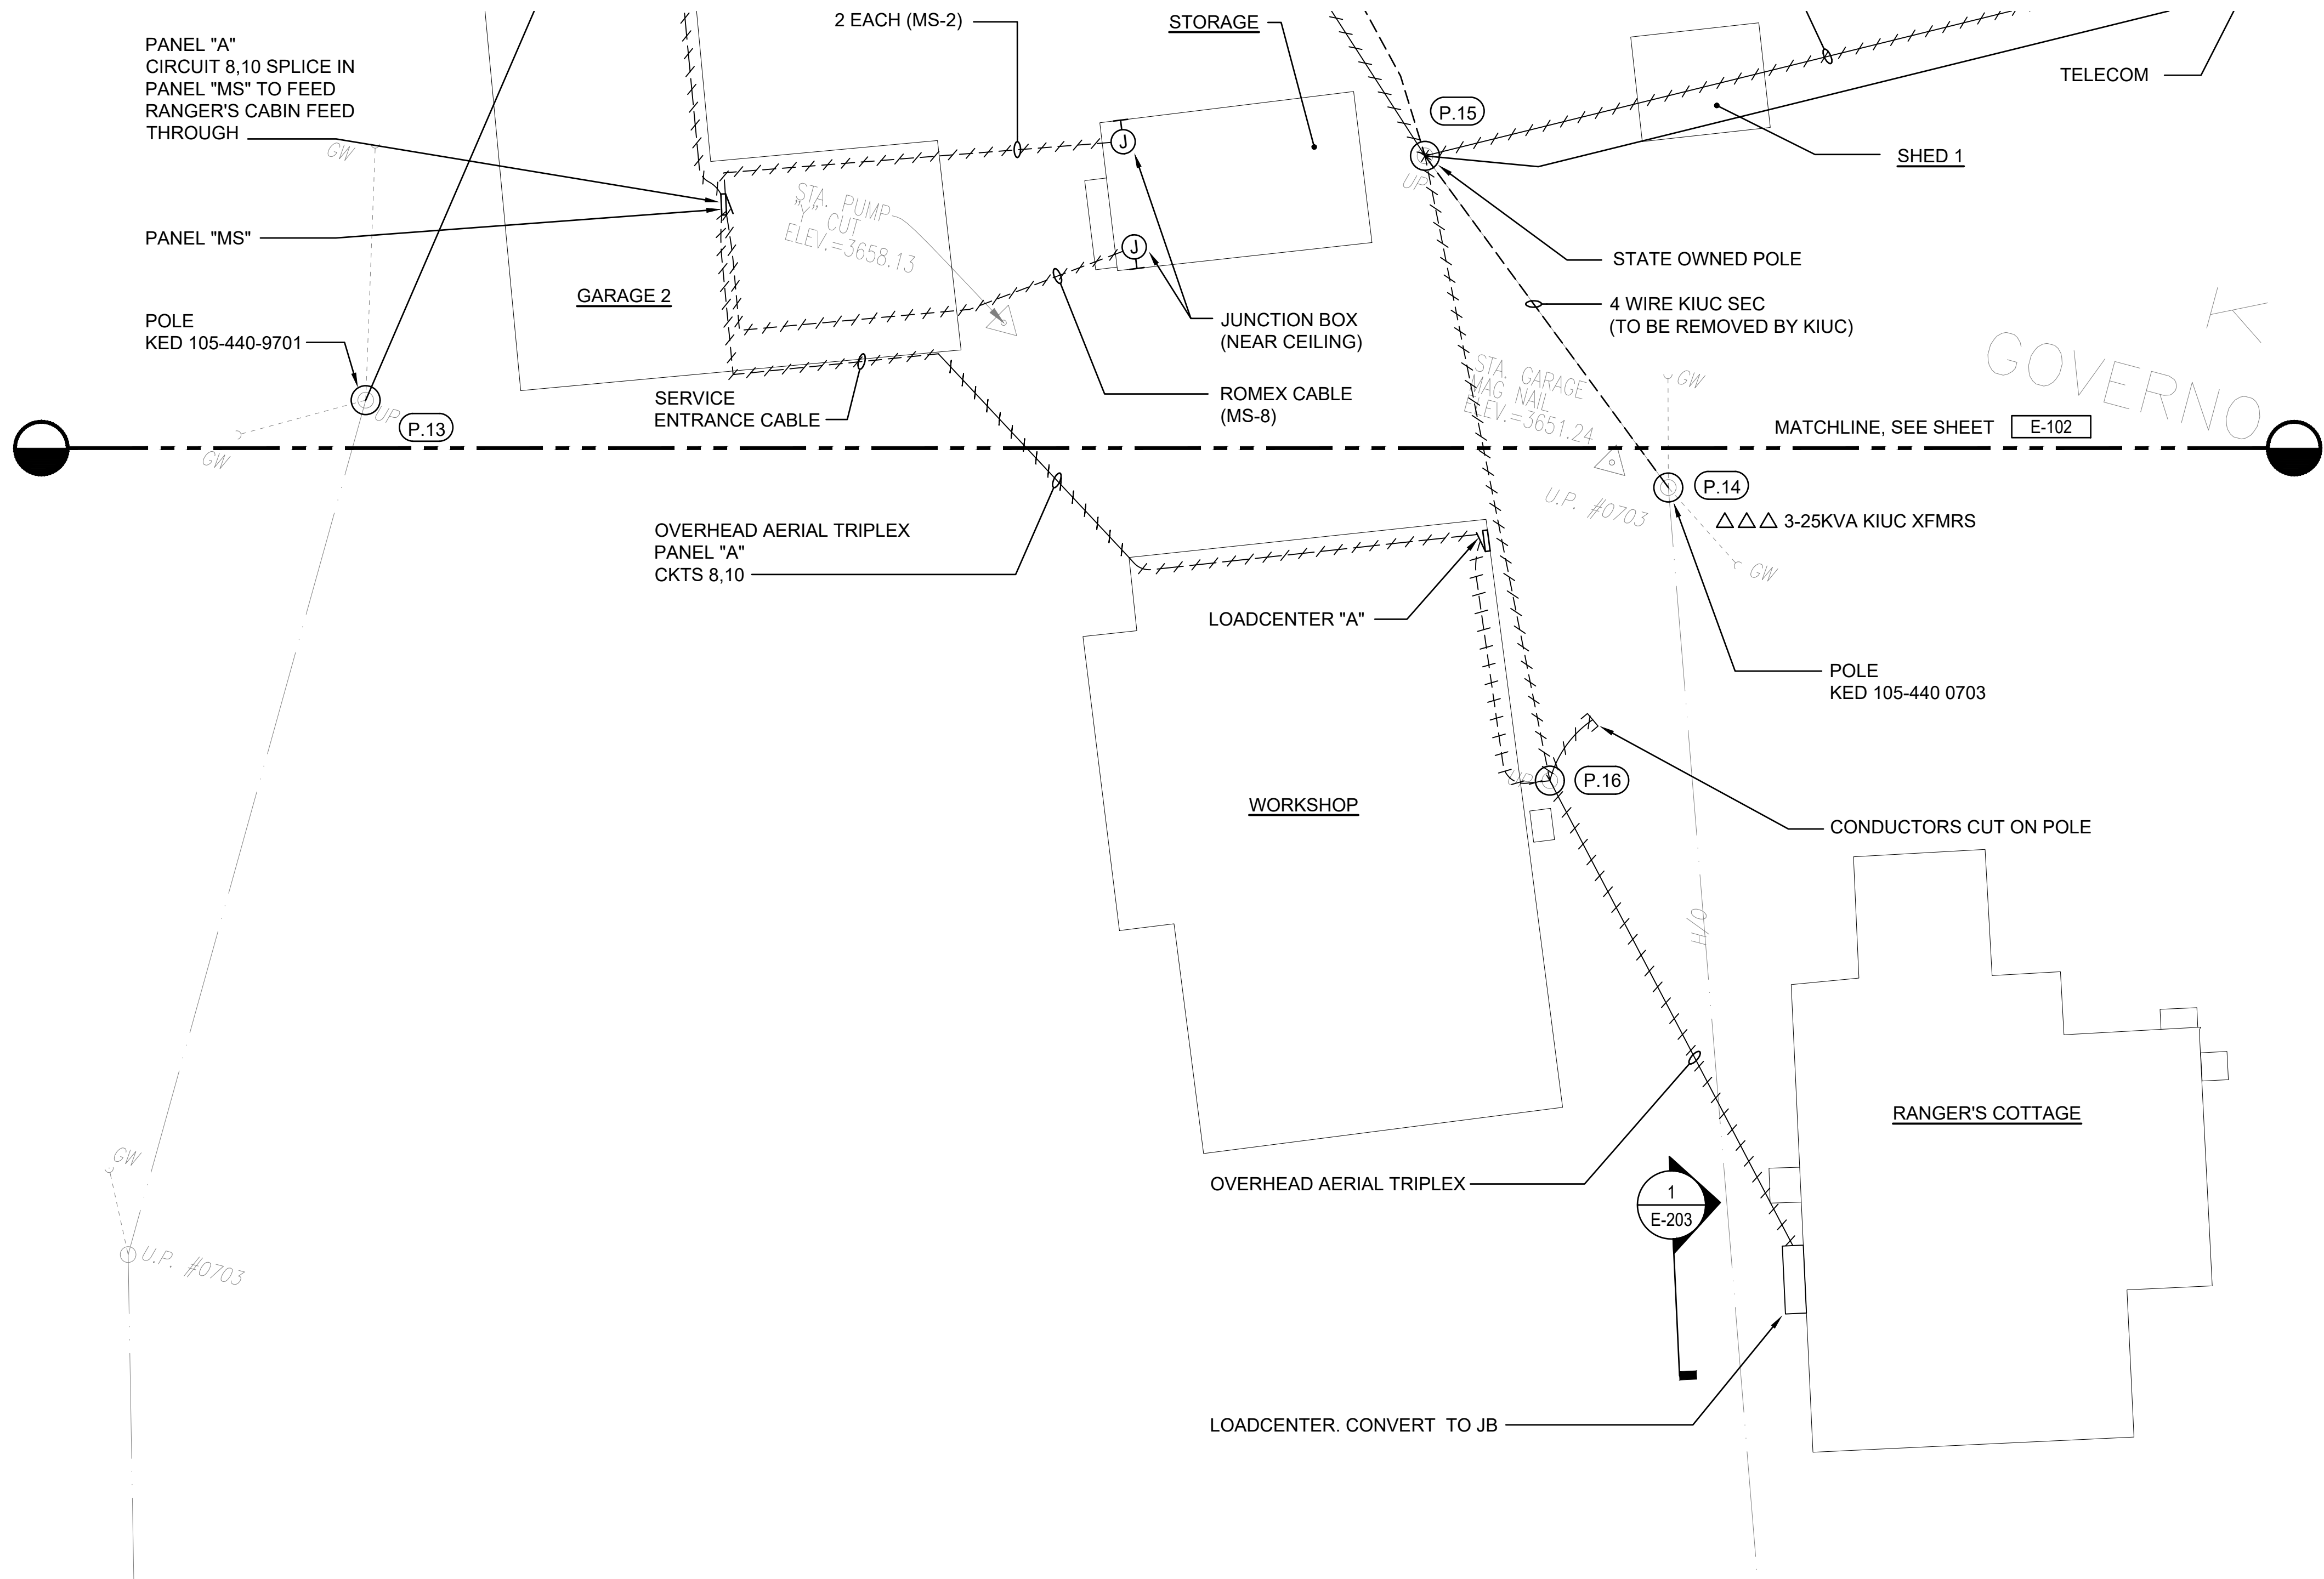


1 ELECTRICAL DEMO PLAN B (WORKSHOP AND RANGER'S COTTAGE)

SCALE: 1"=10'-0"

NOTES:

1. ——— LIGHT LINES DENOTE EXISTING CONDITION
+++++ "I" DENOTES REMOVAL WORK
—R— "R" DENOTES REMOVAL OF EXISTING CONDUCTORS FROM EXISTING CONDUIT. CONDUIT TO BE REUSED.
2. INTERCEPT EXISTING CONDUIT AND CONDUCTORS WITH NEW WIREWAY.
3. CONTRACTOR IS RESPONSIBLE FOR DISPOSAL OF ITEMS TO BE REMOVED.

REVISION NO.	SYM.	DESCRIPTION	SHT./OF	DATE	APPROVED
STATE OF HAWAII DEPARTMENT OF LAND AND NATURAL RESOURCES ENGINEERING DIVISION KOKE'E STATE PARK ELECTRICAL IMPROVEMENTS WAIMEA, KAUAI, HAWAII ELECTRICAL DEMO PLAN B (WORKSHOP AND RANGER'S COTTAGE) FUKUNAGA AND ASSOCIATES, INC					
DESIGNED: ACH		SUBMITTED:			
DRAWN: MKE		DATE: APRIL 2026			
CHECKED: ACH		SCALE: AS SHOWN		DRAWING NO. E-103	
APPROVED: Dina Lau E-signed 2026-05-07 07:15AM HST dina.u.lau@hawaii.gov State of Hawaii Civil Engineer		SHEET NO. 7 OF 21 SHEETS			

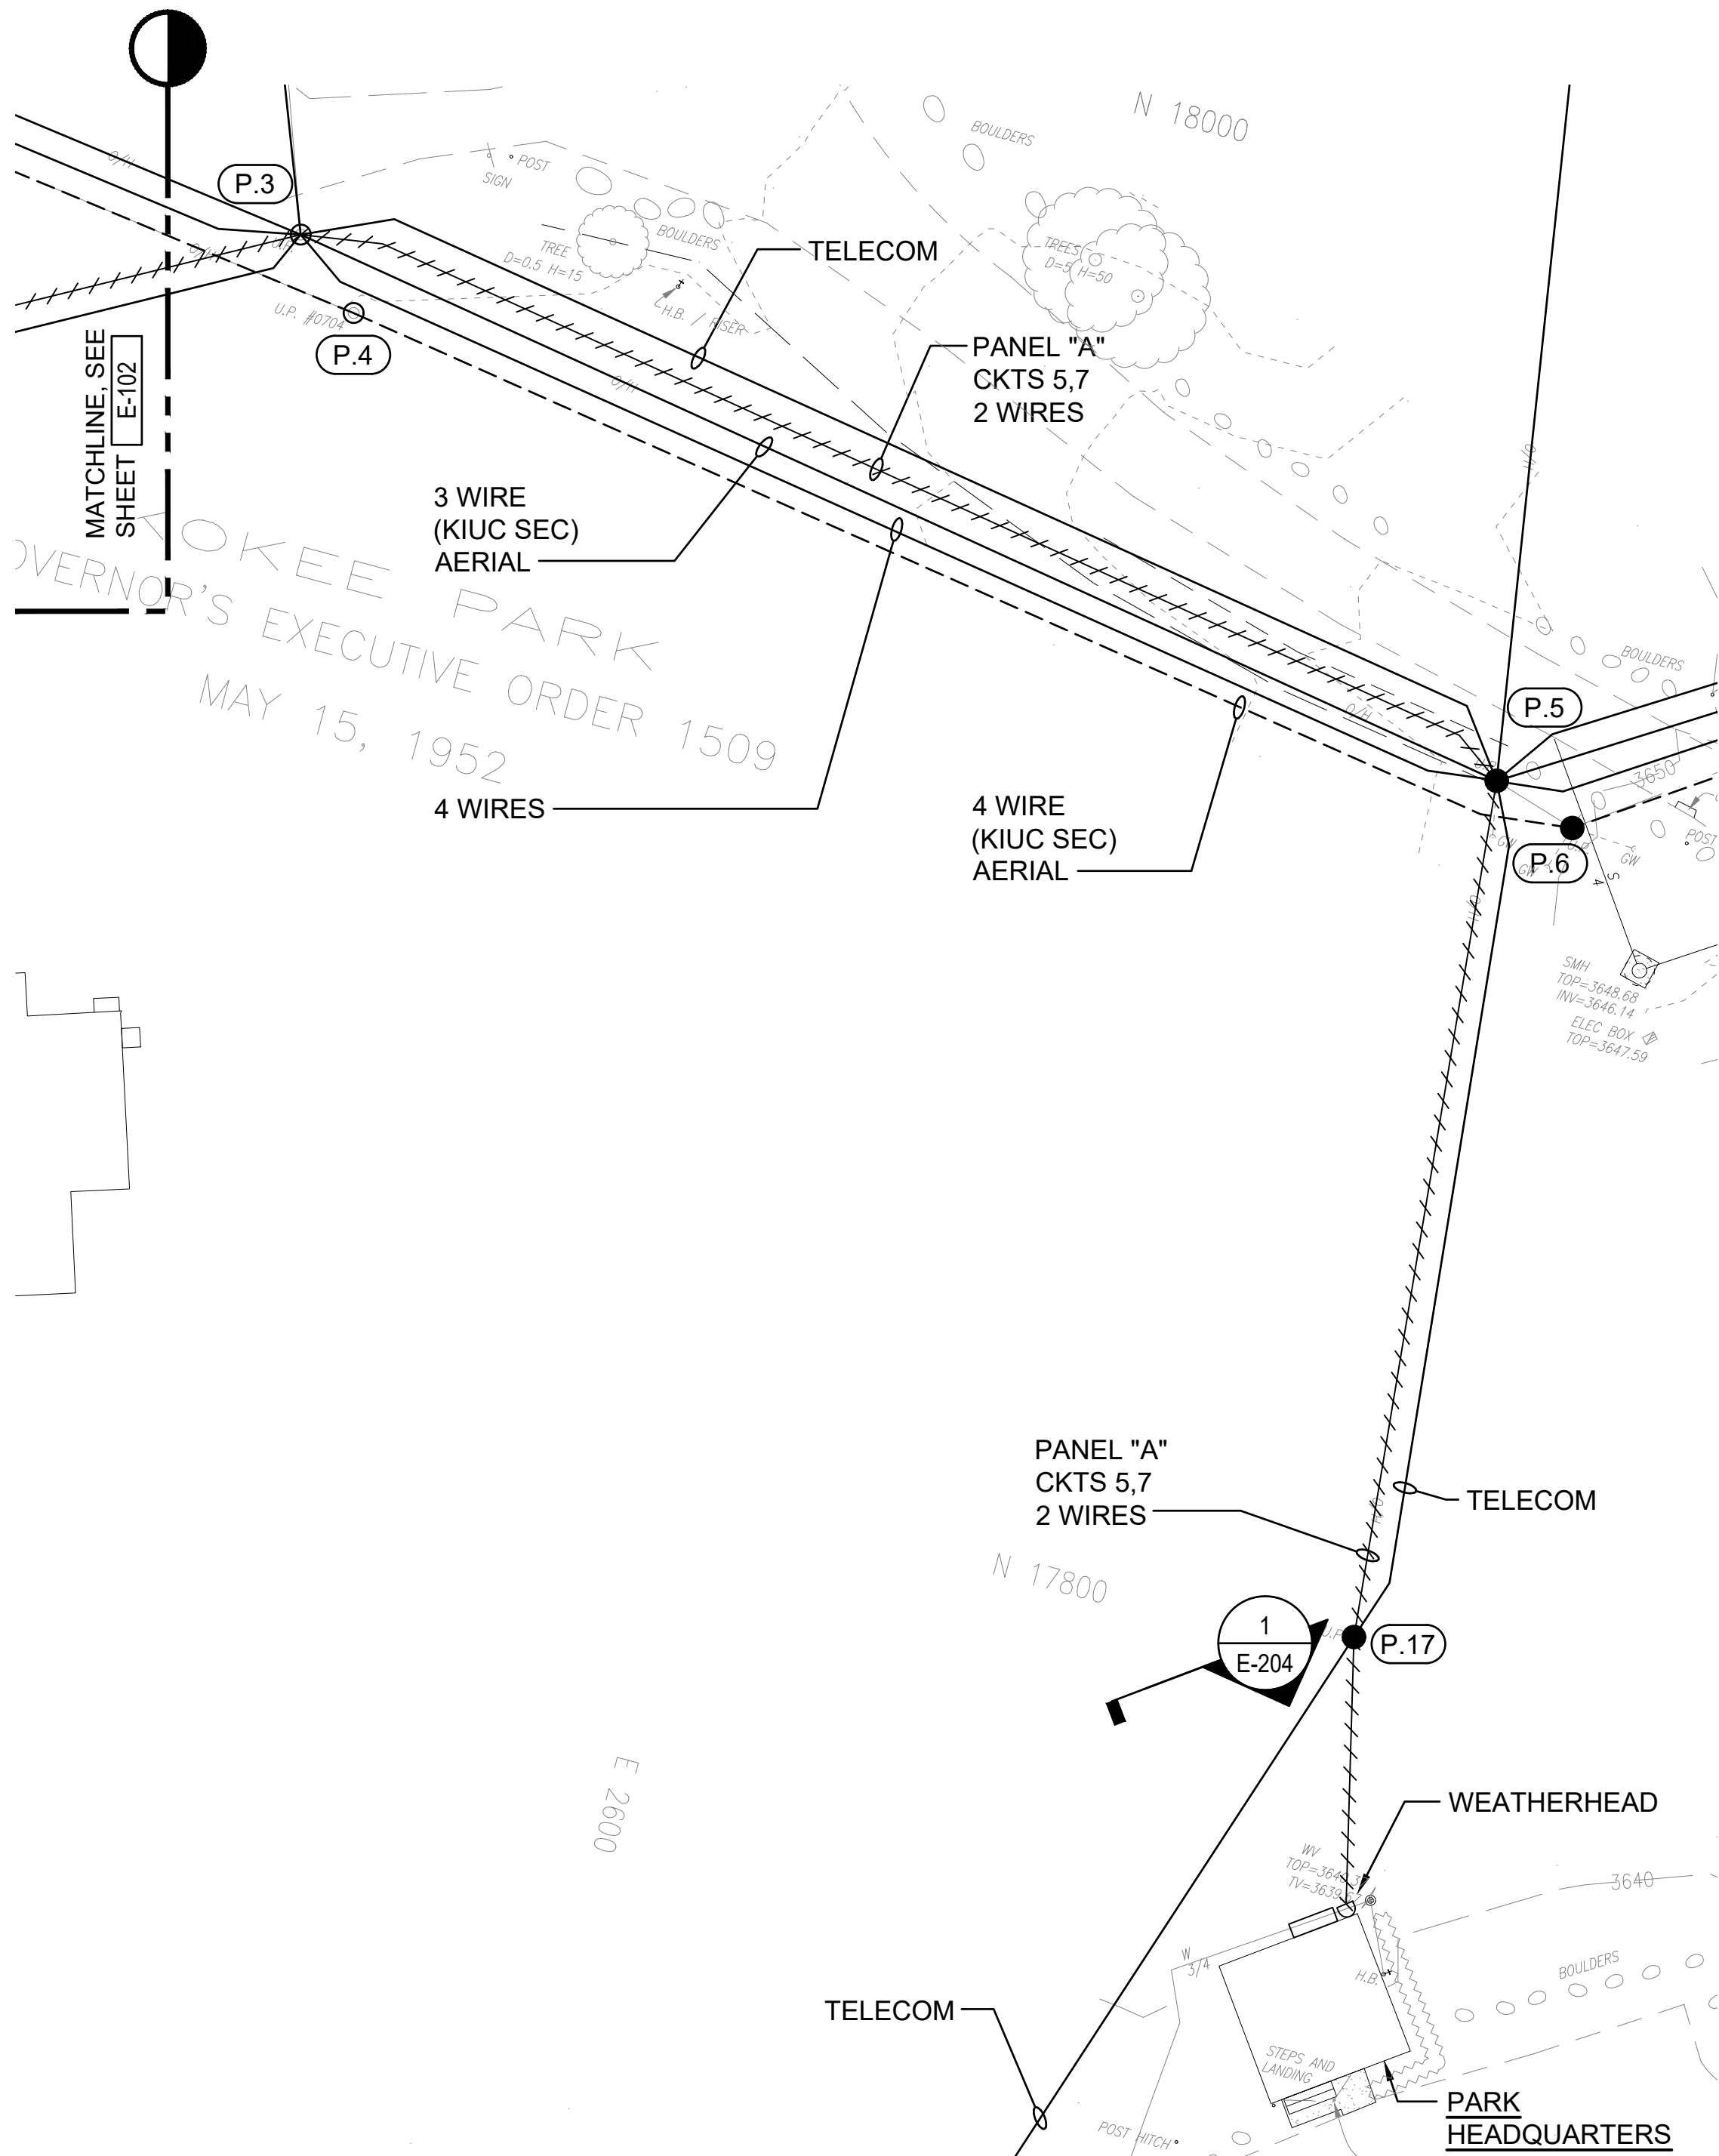


1 ELECTRICAL DEMO PLAN C (PARK HEADQUARTERS)



SCALE: 1" = 20'-0"

NOTES:

- LIGHT LINES DENOTE EXISTING CONDITION
//////// "I" DENOTES REMOVAL WORK
- CONTRACTOR IS RESPONSIBLE FOR DISPOSAL OF ITEMS TO BE REMOVED.

REVISION NO.	SYM.	DESCRIPTION	SHT./OF	DATE	APPROVED
STATE OF HAWAII DEPARTMENT OF LAND AND NATURAL RESOURCES ENGINEERING DIVISION KOKE'E STATE PARK ELECTRICAL IMPROVEMENTS WAIMEA, KAUAI, HAWAII ELECTRICAL DEMO PLAN C (PARK HEADQUARTERS) FUKUNAGA AND ASSOCIATES, INC					
DESIGNED: ACH		SUBMITTED:			
DRAWN: MKE		DATE: APRIL 2026			
CHECKED: ACH		SCALE: AS SHOWN		DRAWING NO. E-104	
APPROVED: Dina Lau E-signed 2026-05-07 07:15AM HST dina.u.lau@hawaii.gov State of Hawaii CHIEF ENGINEER		CIVIL ENGINEER			

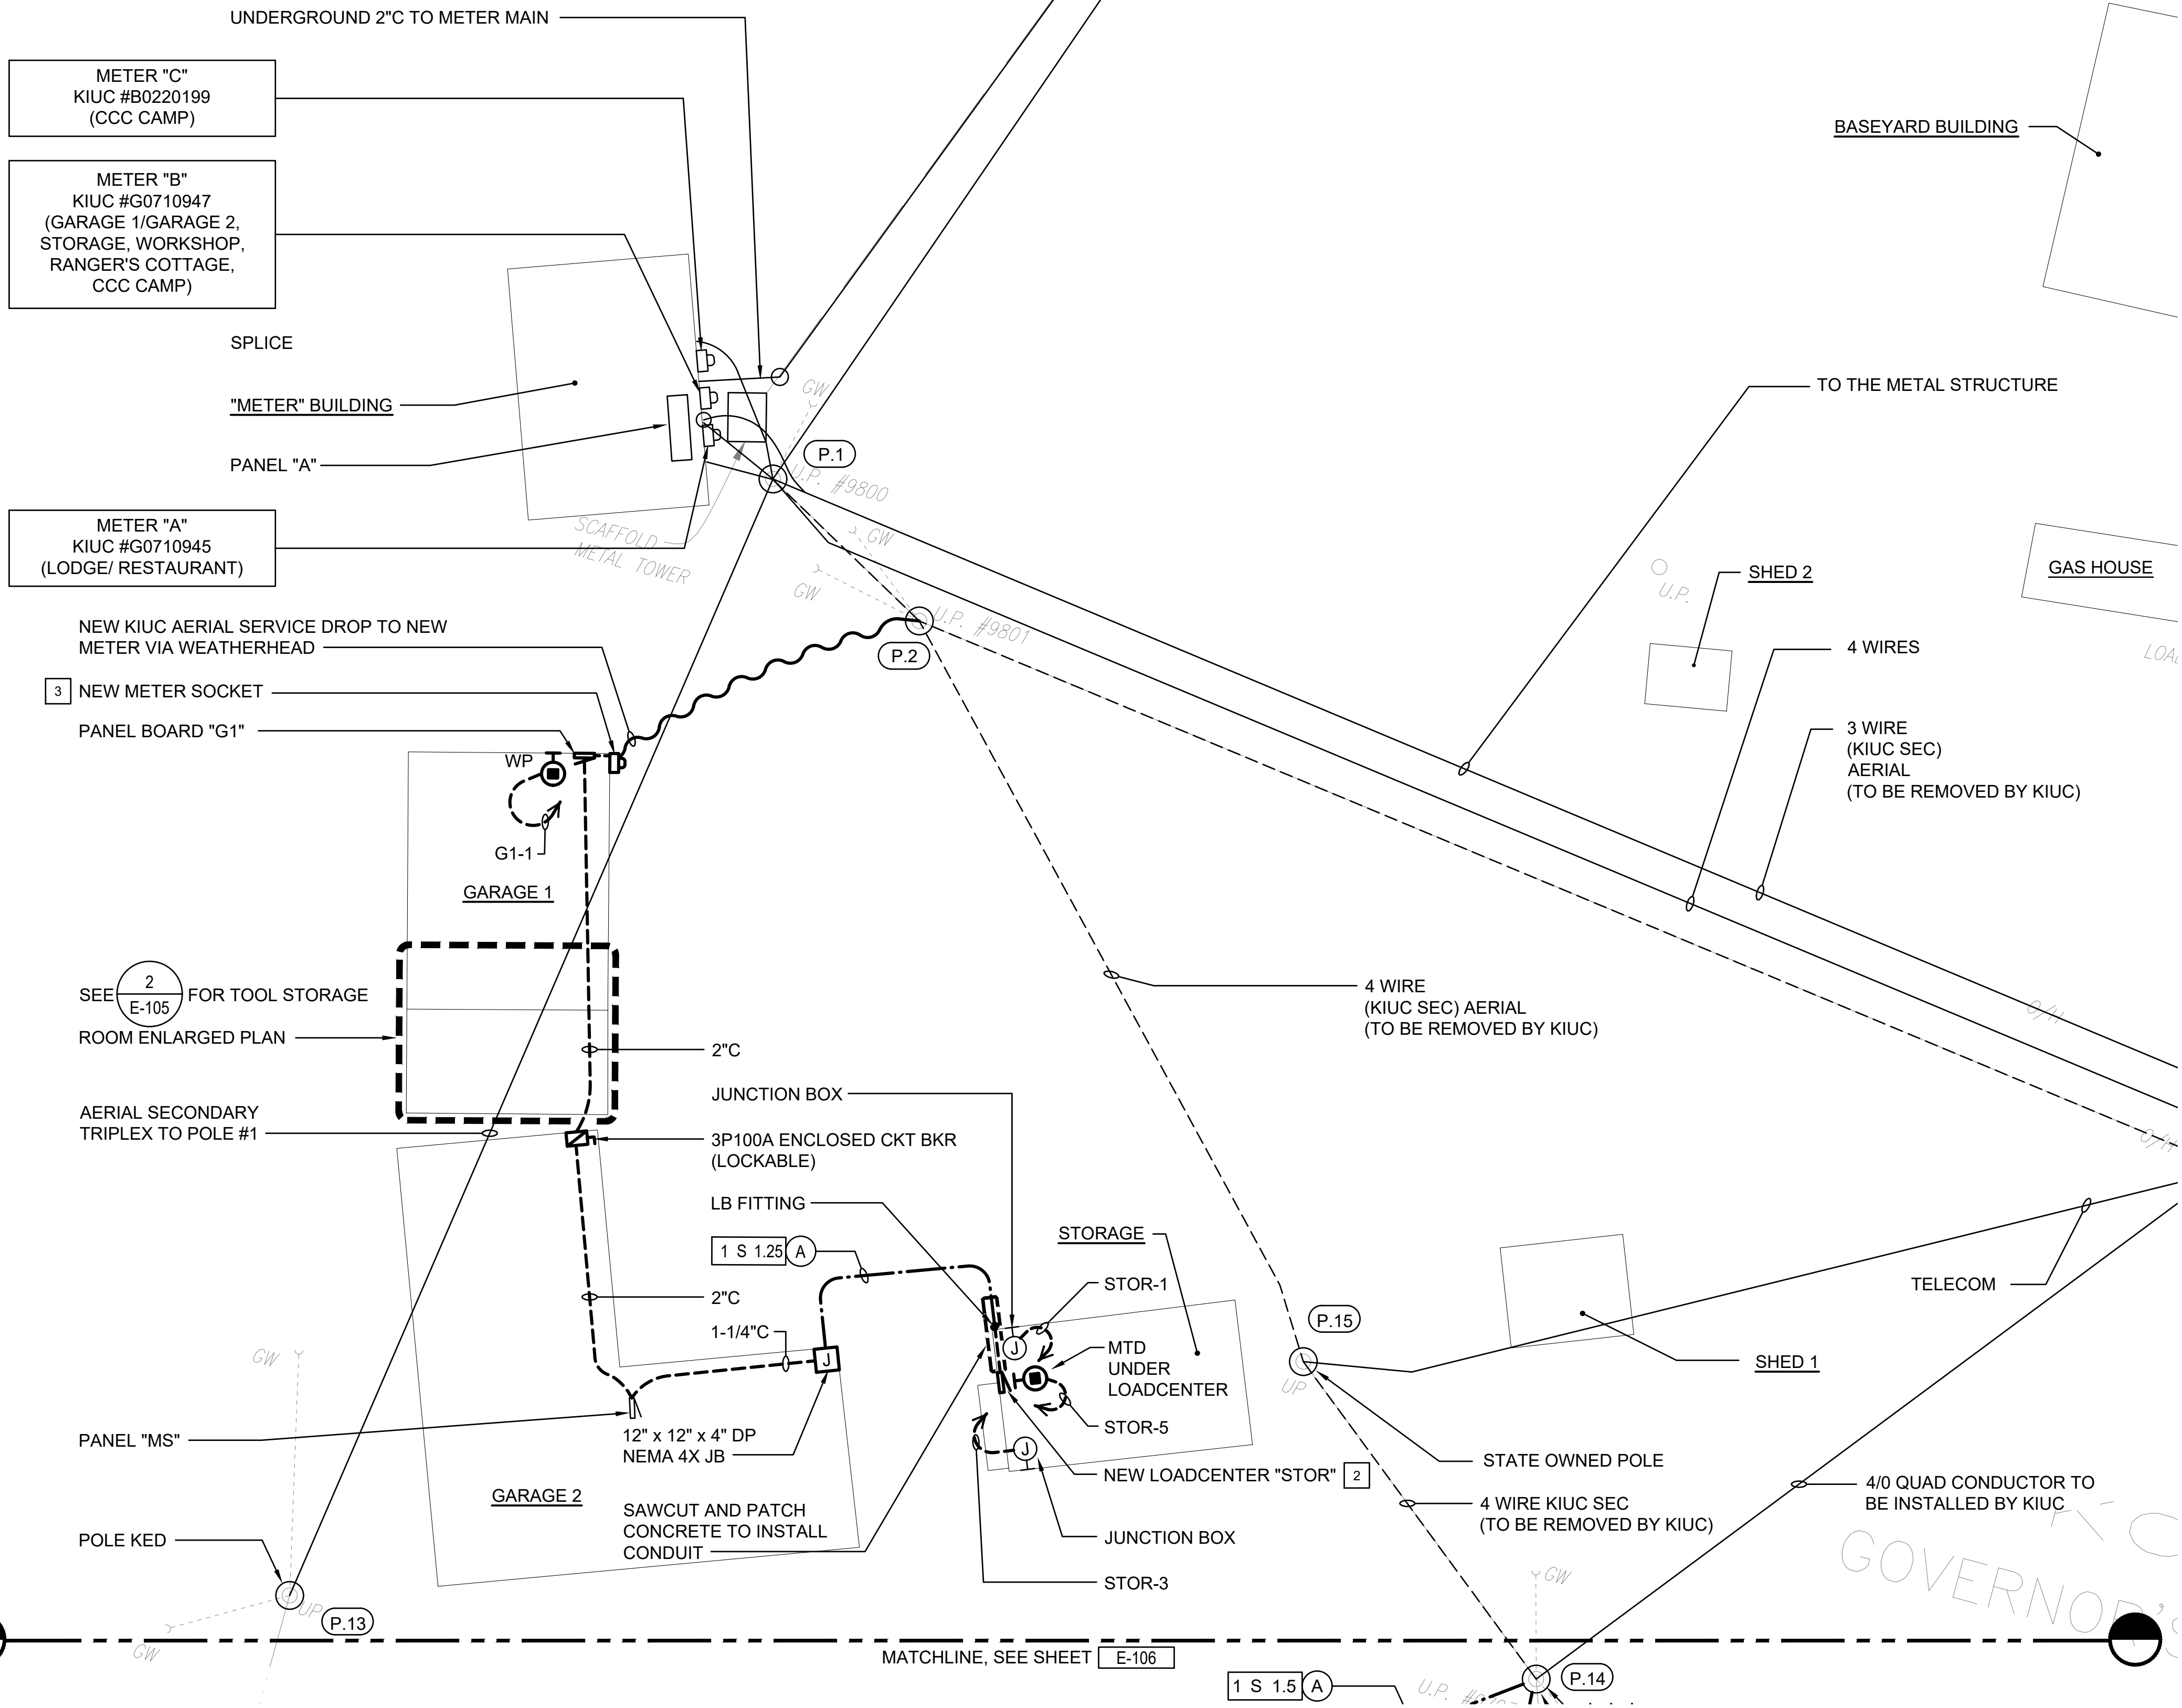

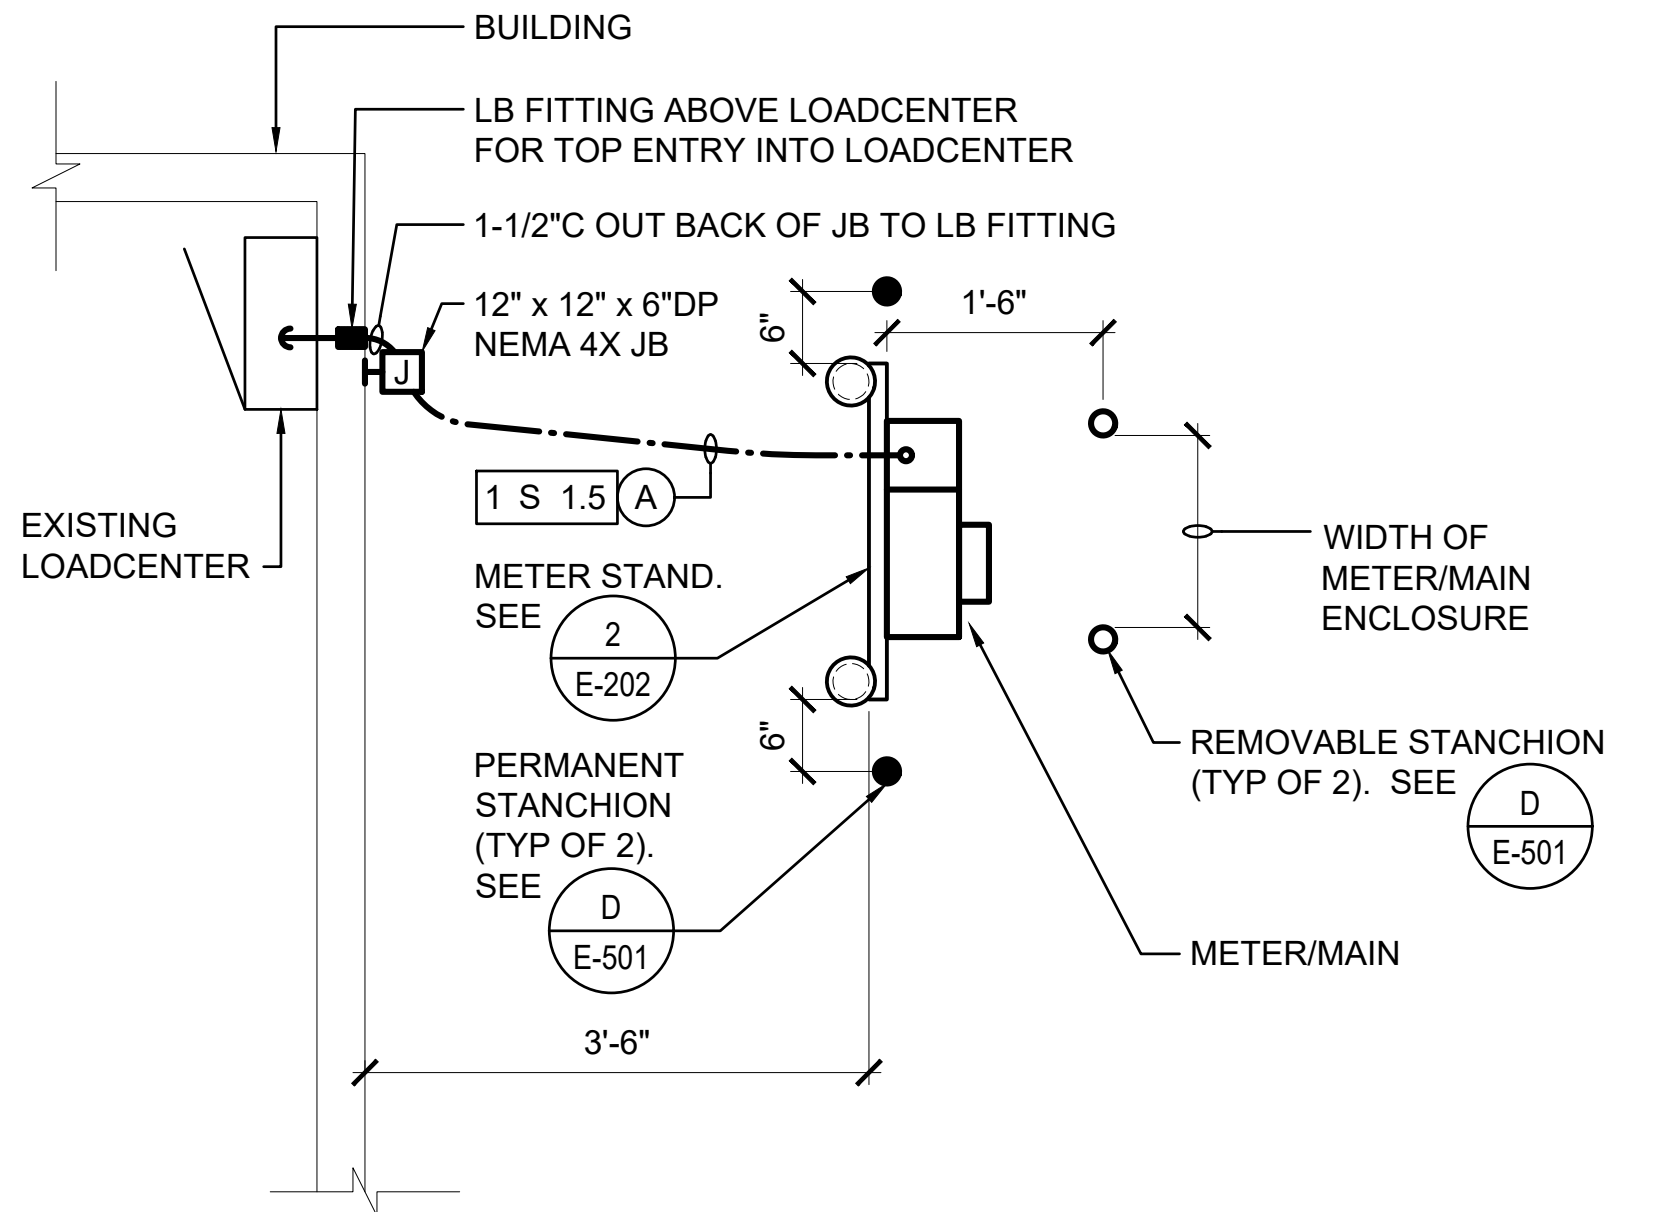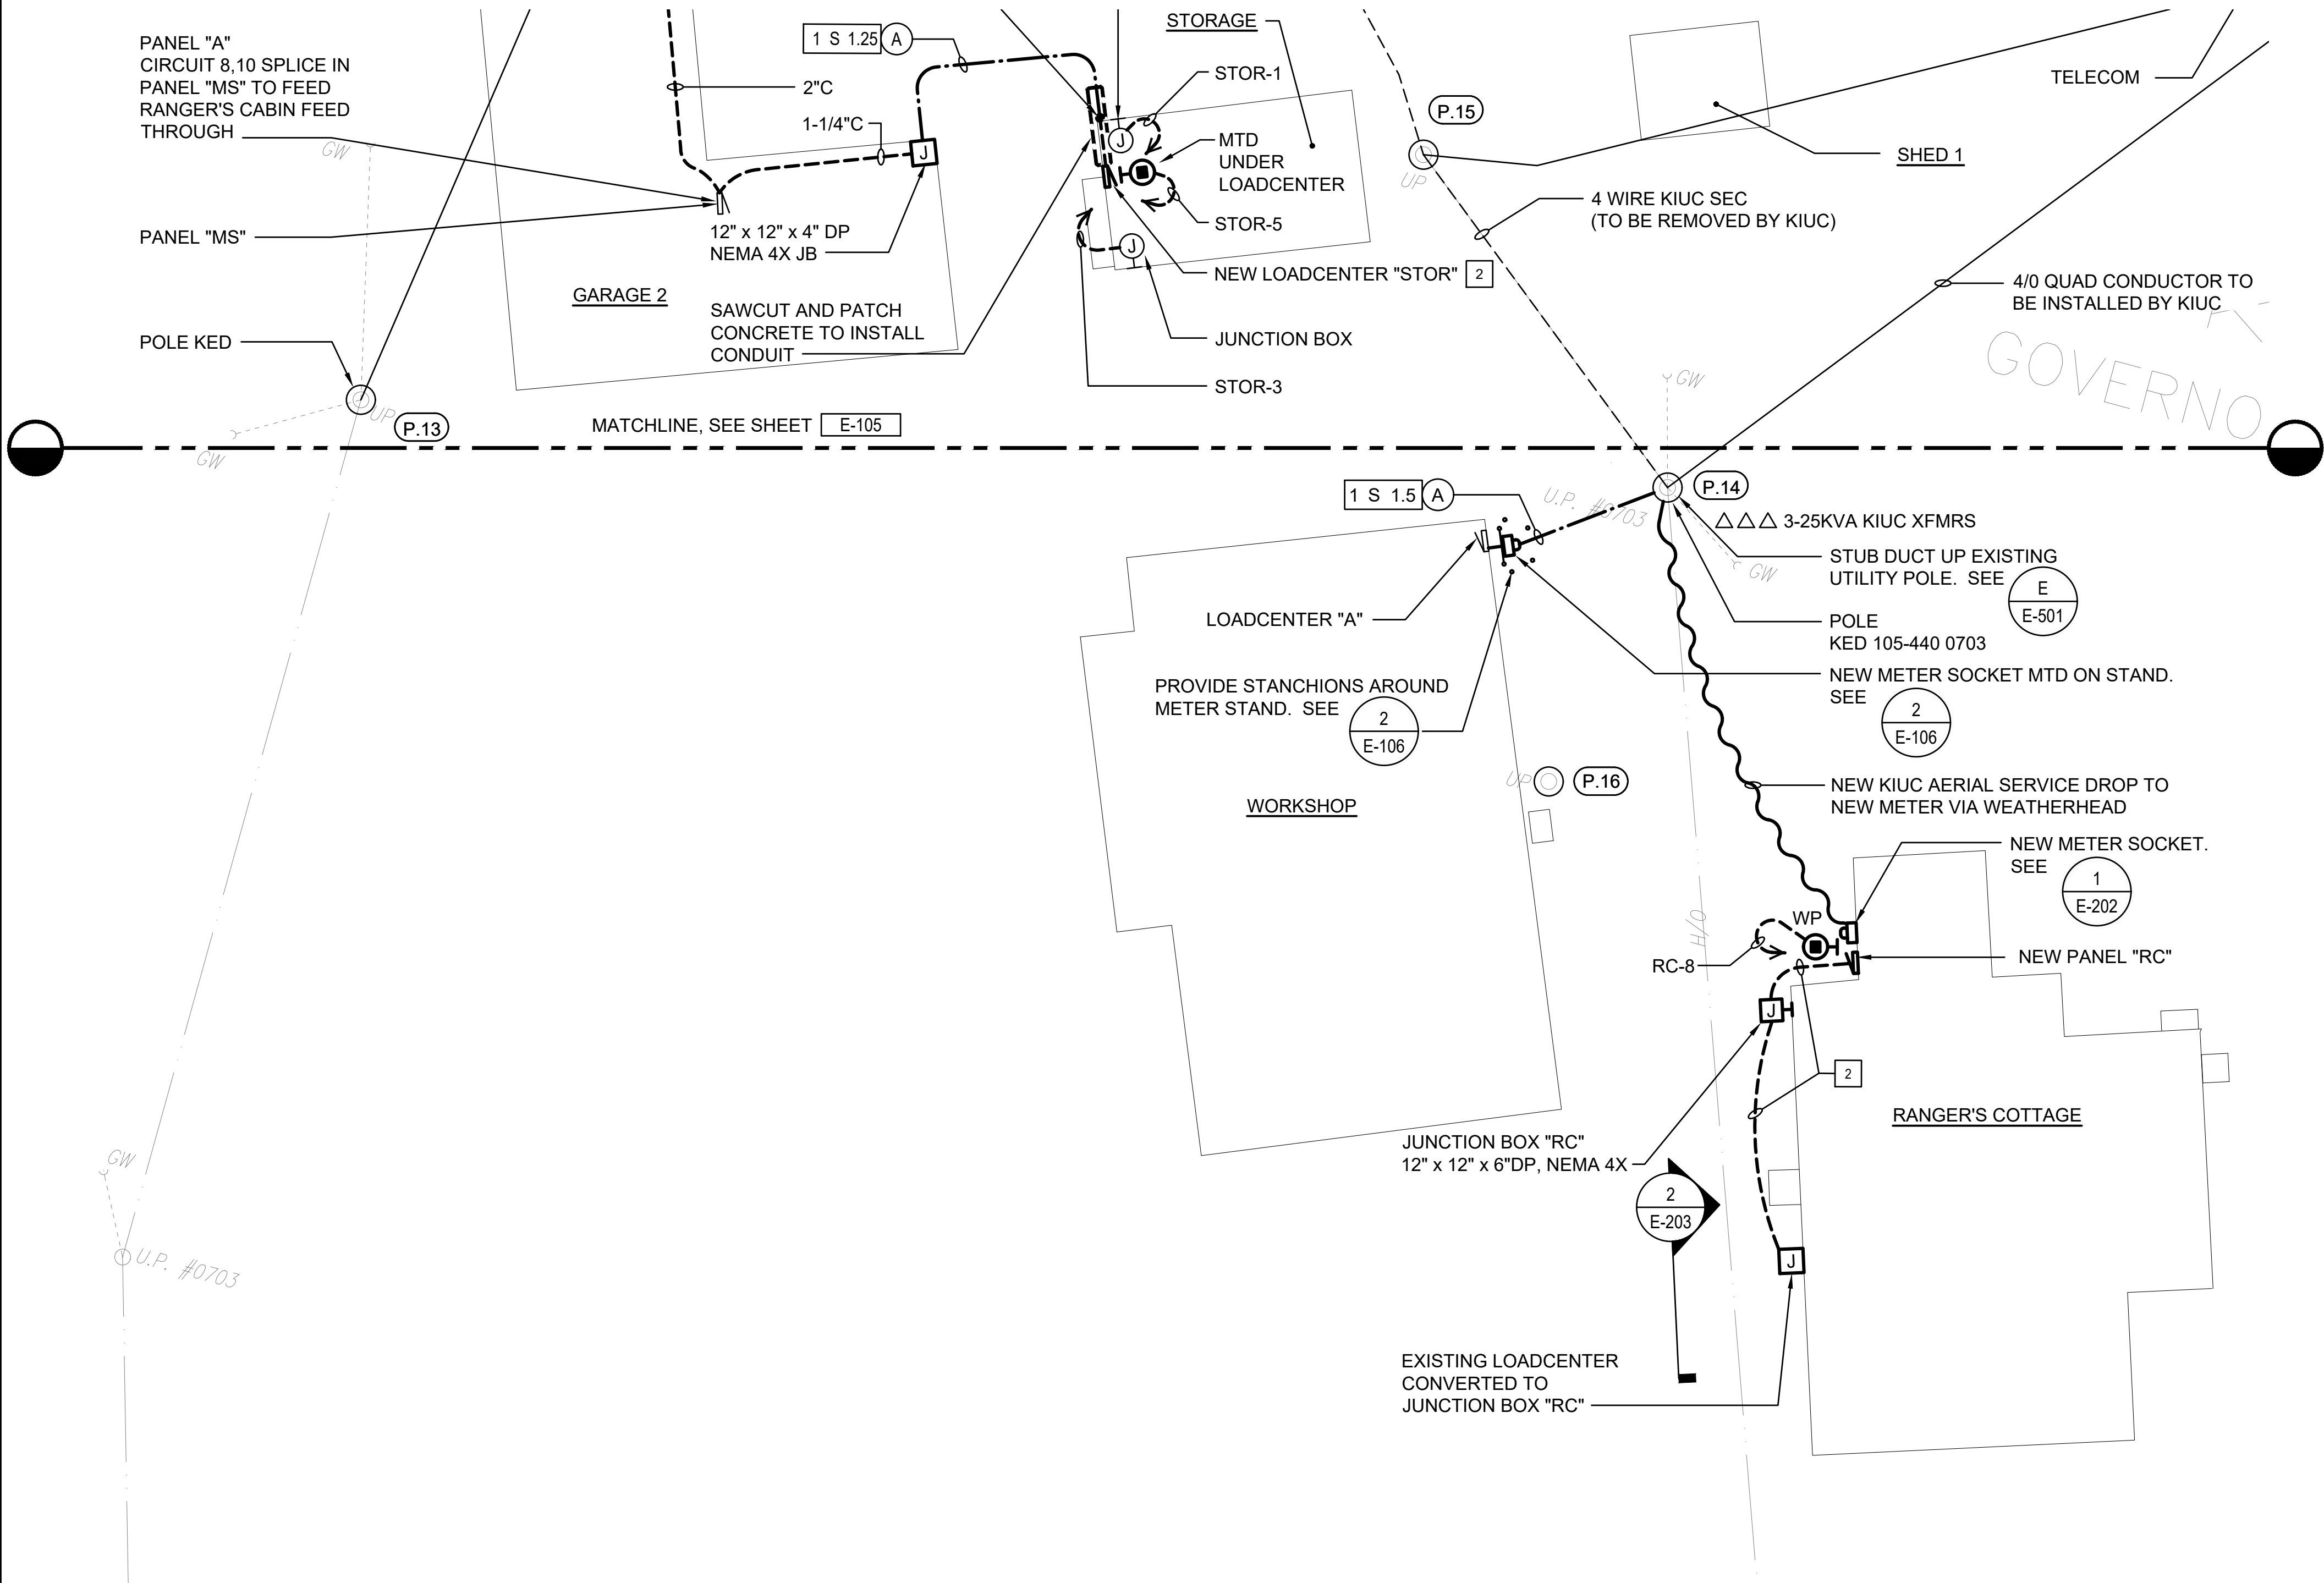

2 WORKSHOP METER ENLARGED PLAN
SCALE: 3/4" = 1'-0"

NOTES:

1. LIGHT LINES DENOTE EXISTING CONDITION
2. BOLD LINES DENOTE NEW WORK

1 ELECTRICAL PLAN B (WORKSHOP AND RANGER'S COTTAGE)


SCALE: 1" = 10'-0"

NOTES:

1. LIGHT LINES DENOTE EXISTING CONDITION
2. BOLD LINES DENOTE NEW WORK


2 SEE ONE-LINE DIAGRAM FOR ADDITIONAL INFORMATION.

REVISION NO.	SYM.	DESCRIPTION	SHT./OF	DATE	APPROVED
STATE OF HAWAII DEPARTMENT OF LAND AND NATURAL RESOURCES ENGINEERING DIVISION					
KOKE'E STATE PARK ELECTRICAL IMPROVEMENTS WAIMEA, KAUAI, HAWAII					
ELECTRICAL PLAN B (WORKSHOP AND RANGER'S COTTAGE)					
FUKUNAGA AND ASSOCIATES, INC					
DESIGNED: ACH		SUBMITTED:			
DRAWN: MKE		DATE: APRIL 2026			
CHECKED: ACH		SCALE: AS SHOWN			
APPROVED: Dina Lau E-signed 2026-05-07 07:15AM HST dina.u.lau@hawaii.gov State of Hawaii Civil Engineer		DRAWING NO. E-106			

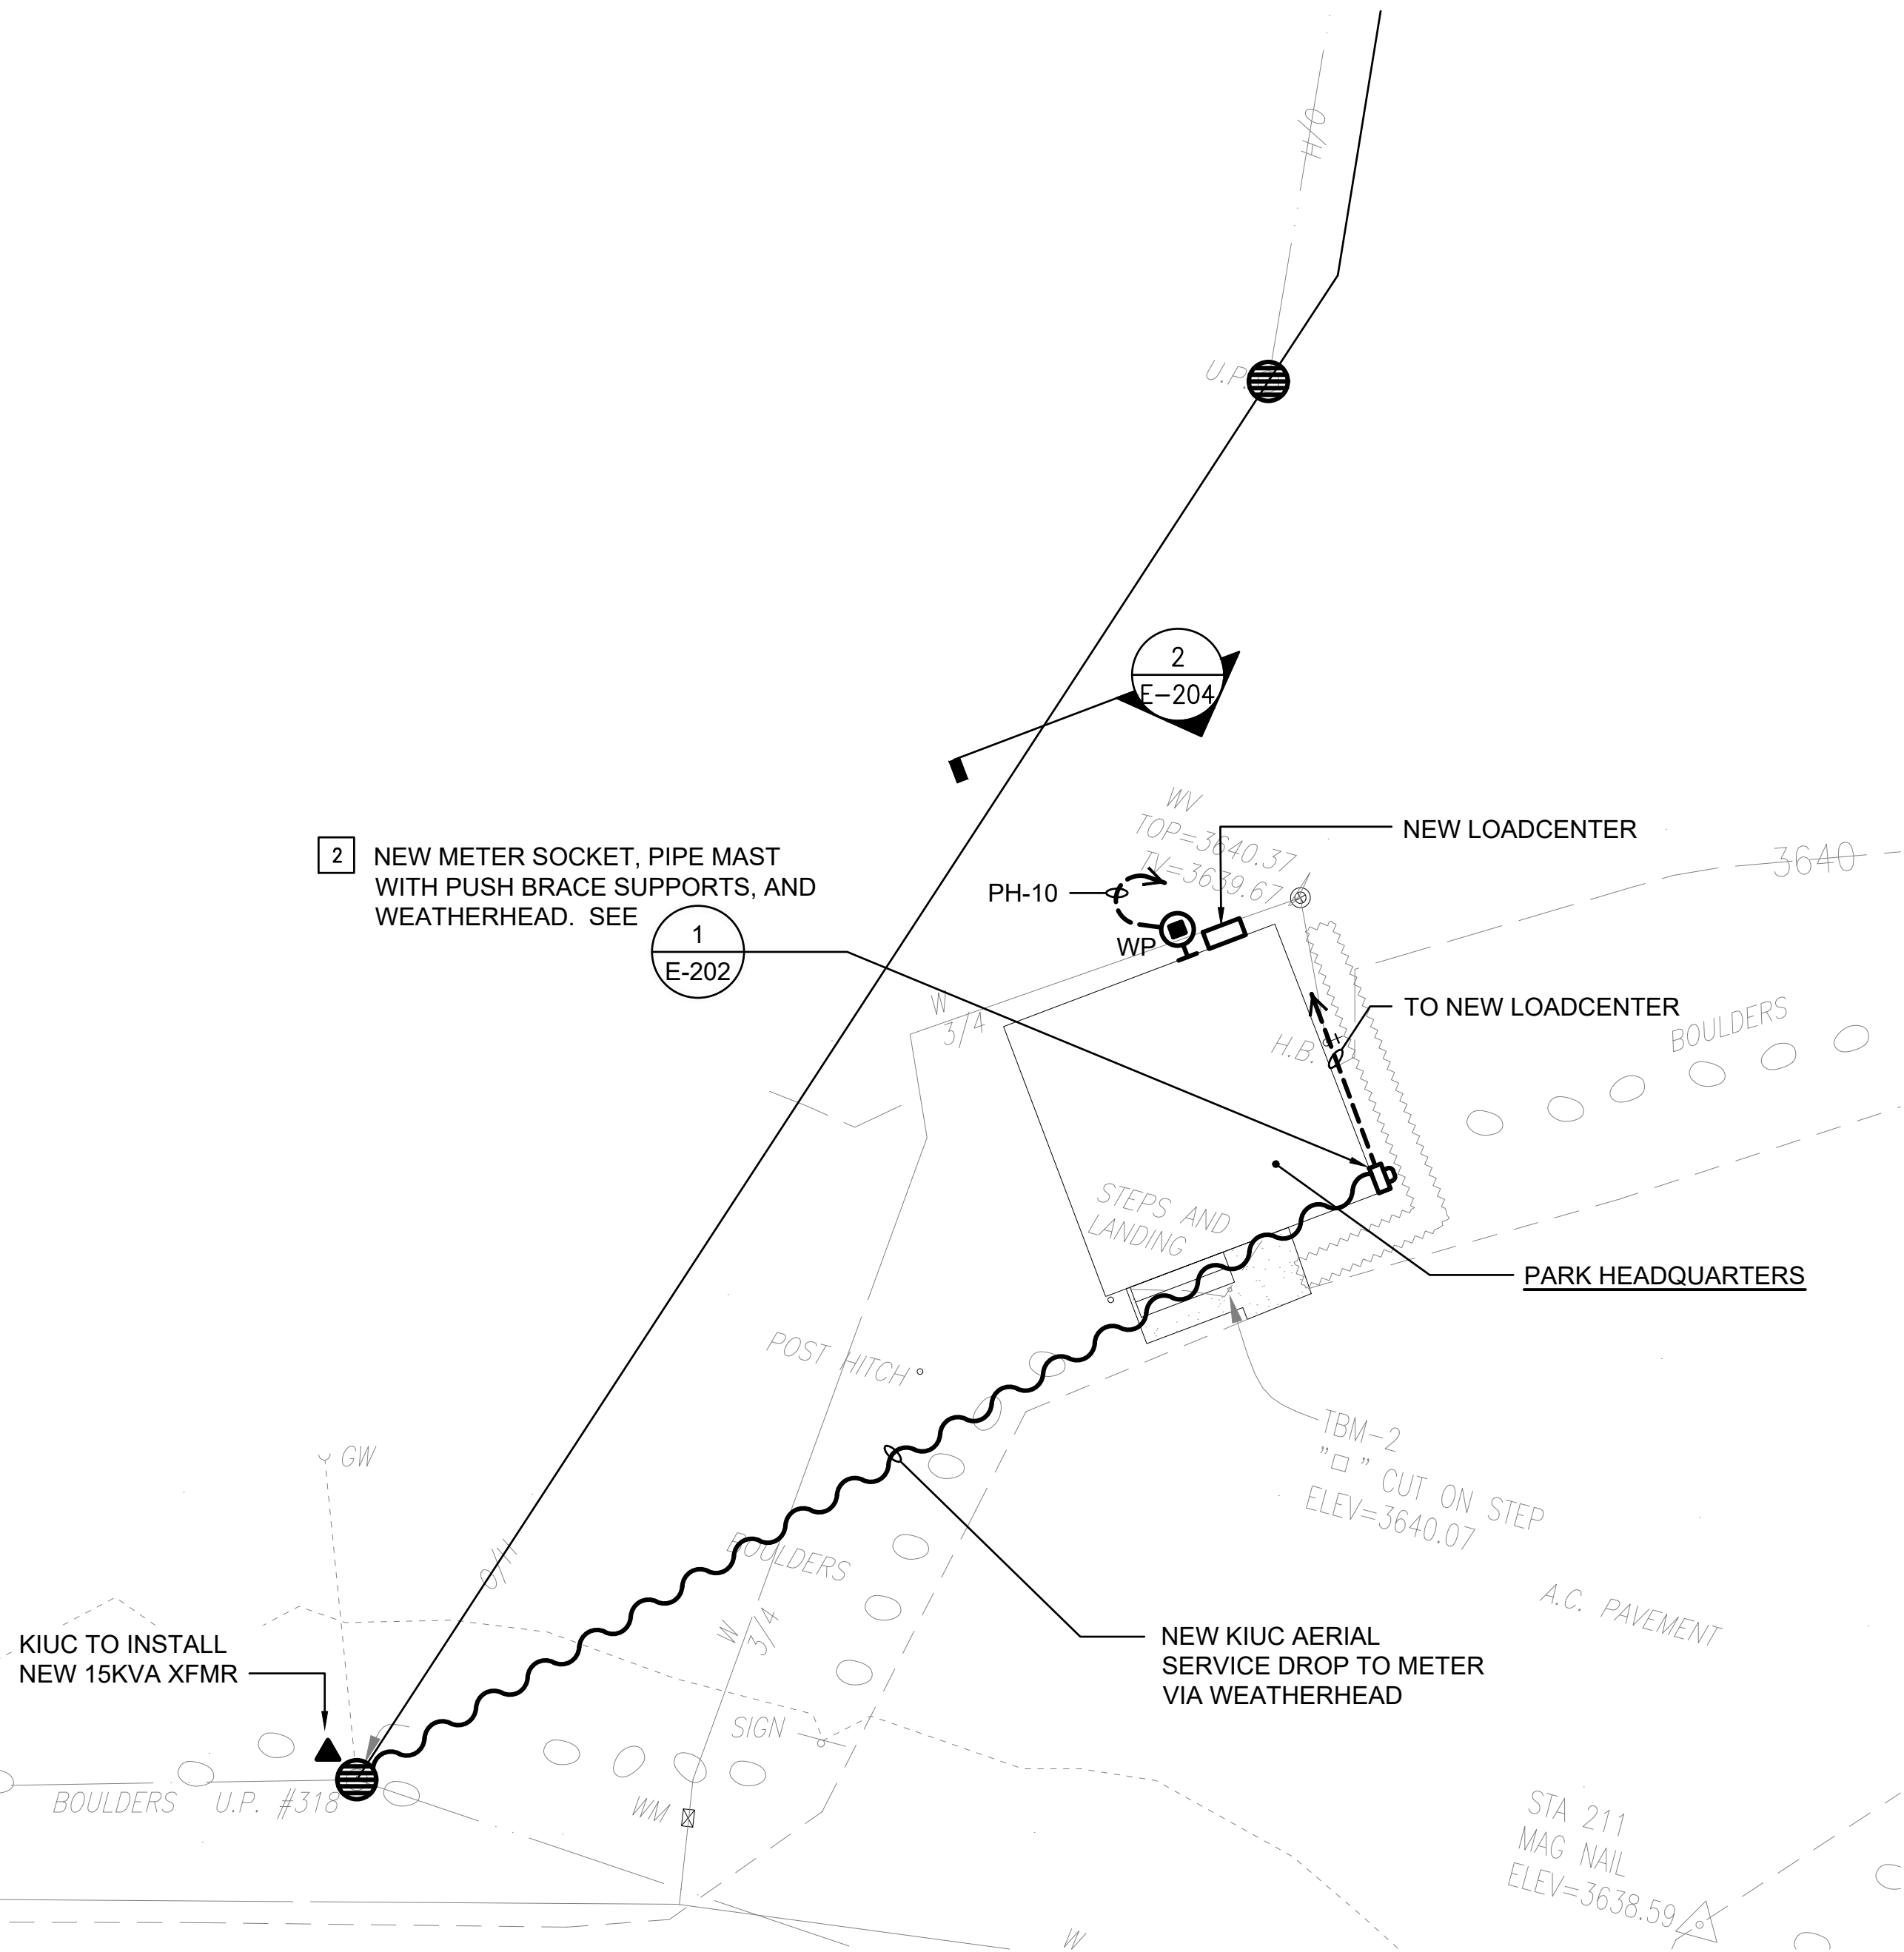

- 1 ELECTRICAL PLAN C (PARK HEADQUARTERS)**
SCALE: 1" = 10'-0"
- NOTES:**
1. ——— LIGHT LINES DENOTE EXISTING CONDITION
——— BOLD LINES DENOTE NEW WORK
- 2** COORDINATE PIPE MAST AND WEATHERHEAD SUPPORT WITH KIUC.

REVISION NO.	SYM.	DESCRIPTION	SHT./OF	DATE	APPROVED
STATE OF HAWAII DEPARTMENT OF LAND AND NATURAL RESOURCES ENGINEERING DIVISION KOKE'E STATE PARK ELECTRICAL IMPROVEMENTS WAIMEA, KAUAI, HAWAII ELECTRICAL PLAN C (PARK HEADQUARTERS) FUKUNAGA AND ASSOCIATES, INC.					
DESIGNED: ACH		SUBMITTED:			
DRAWN: MKE		DATE: APRIL 2026			
CHECKED: ACH		SCALE: AS SHOWN		DRAWING NO. E-107	
APPROVED: Dina Lau E-signed 2026-05-07 07:15AM HST dina.u.lau@hawaii.gov State of Hawaii Civil Engineer		SHEET NO. 11 OF 21 SHEETS			

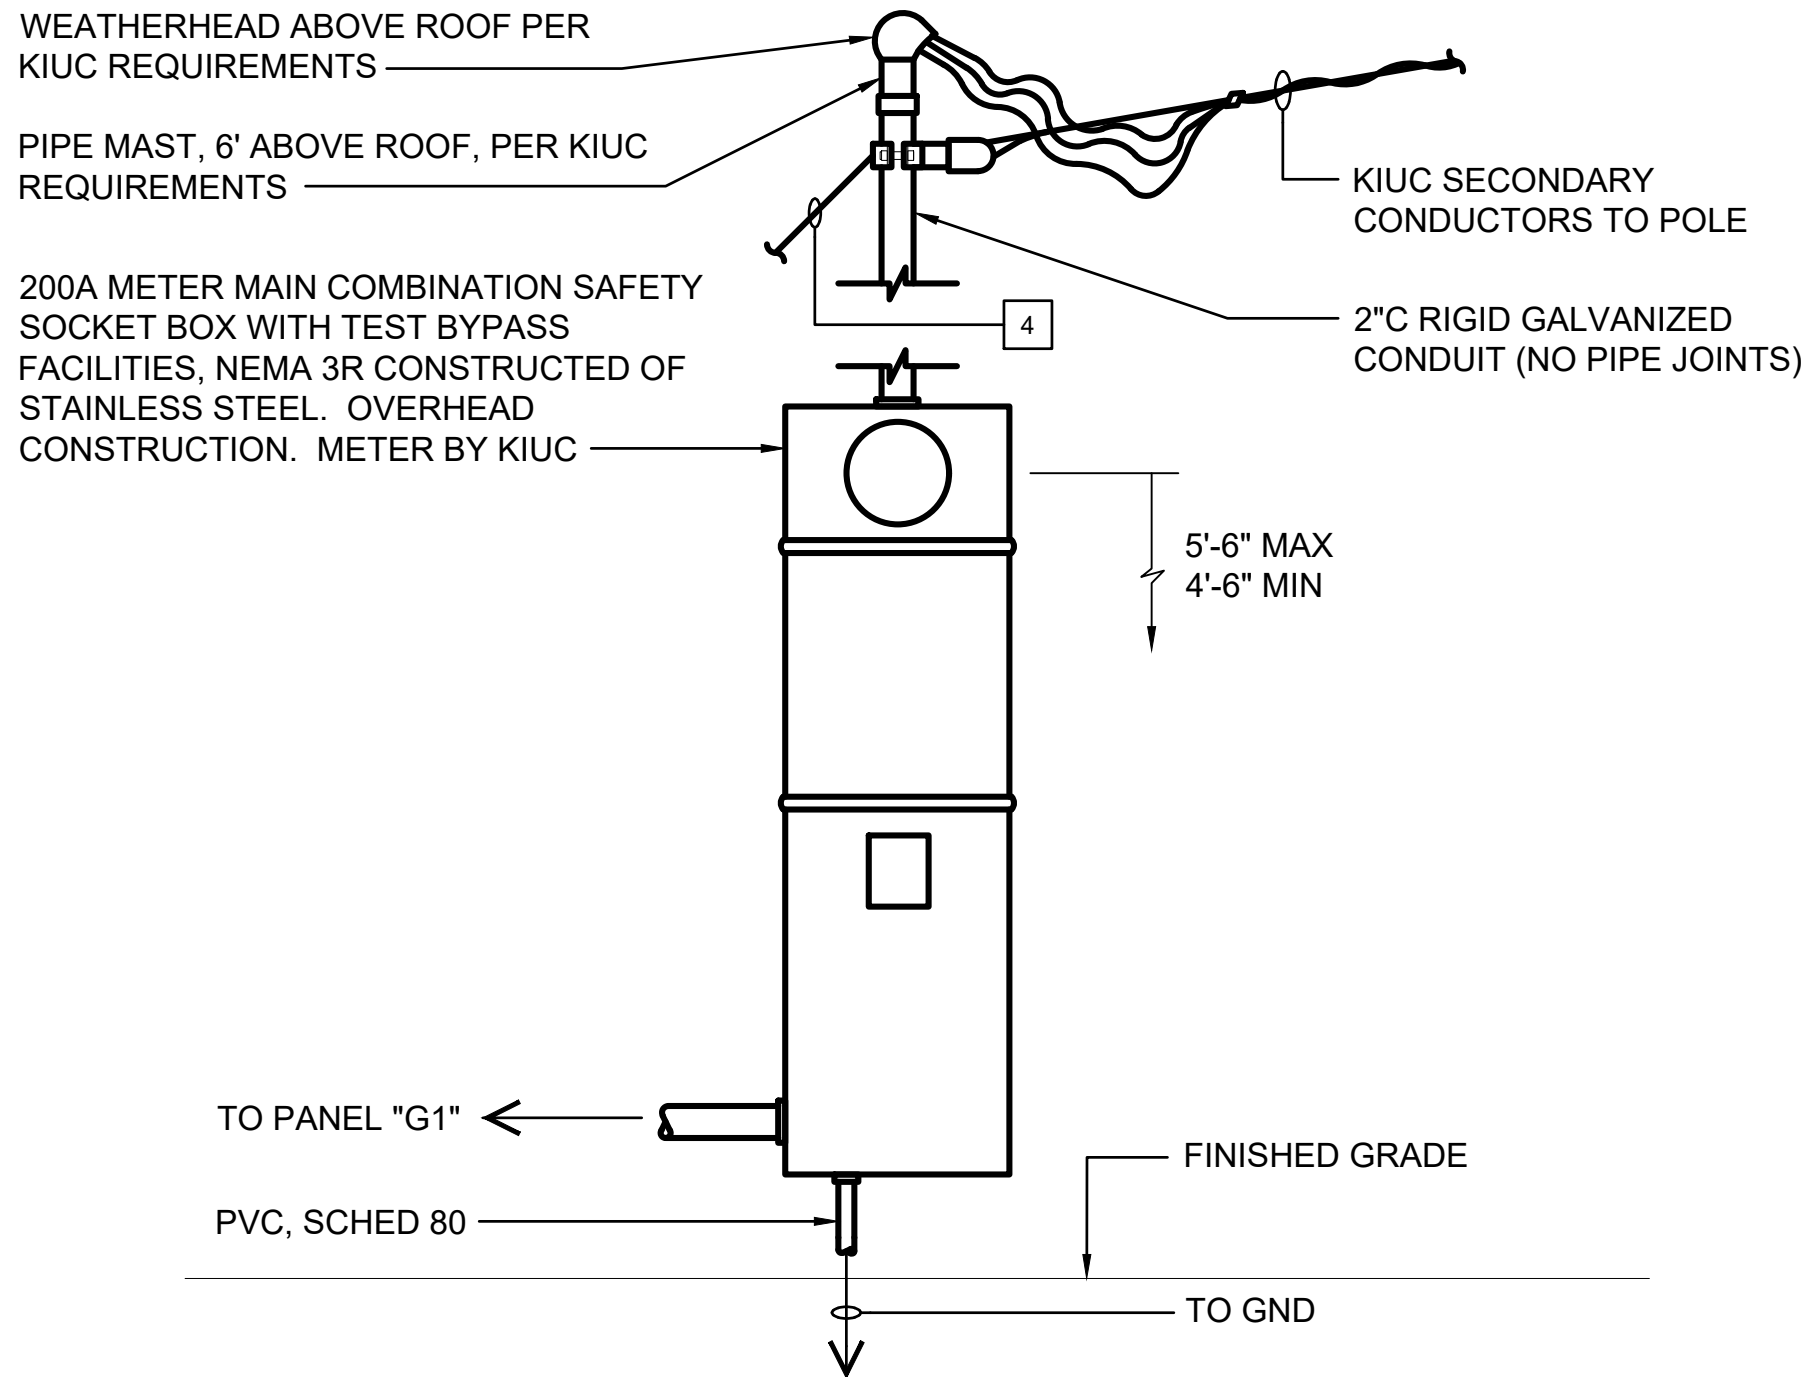

1 METER/SERVICE ENTRANCE ELEVATION - GARAGE 1


SCALE: 1" = 1'-0"



NOTES:


1. LIGHT LINES DENOTE EXISTING CONDITION
BOLD LINES DENOTE NEW WORK
"/" DENOTES REMOVAL WORK
2. CIRCUIT BREAKER AND DISCONNECT SHALL BE NEMA 4X.
3. METER SOCKET/METER MUST BE ACCESSIBLE AT ALL TIMES.

4 GUY TO ROOF. SEE KIUC DETAIL 2
E-202 FOR ADDITIONAL INFORMATION.

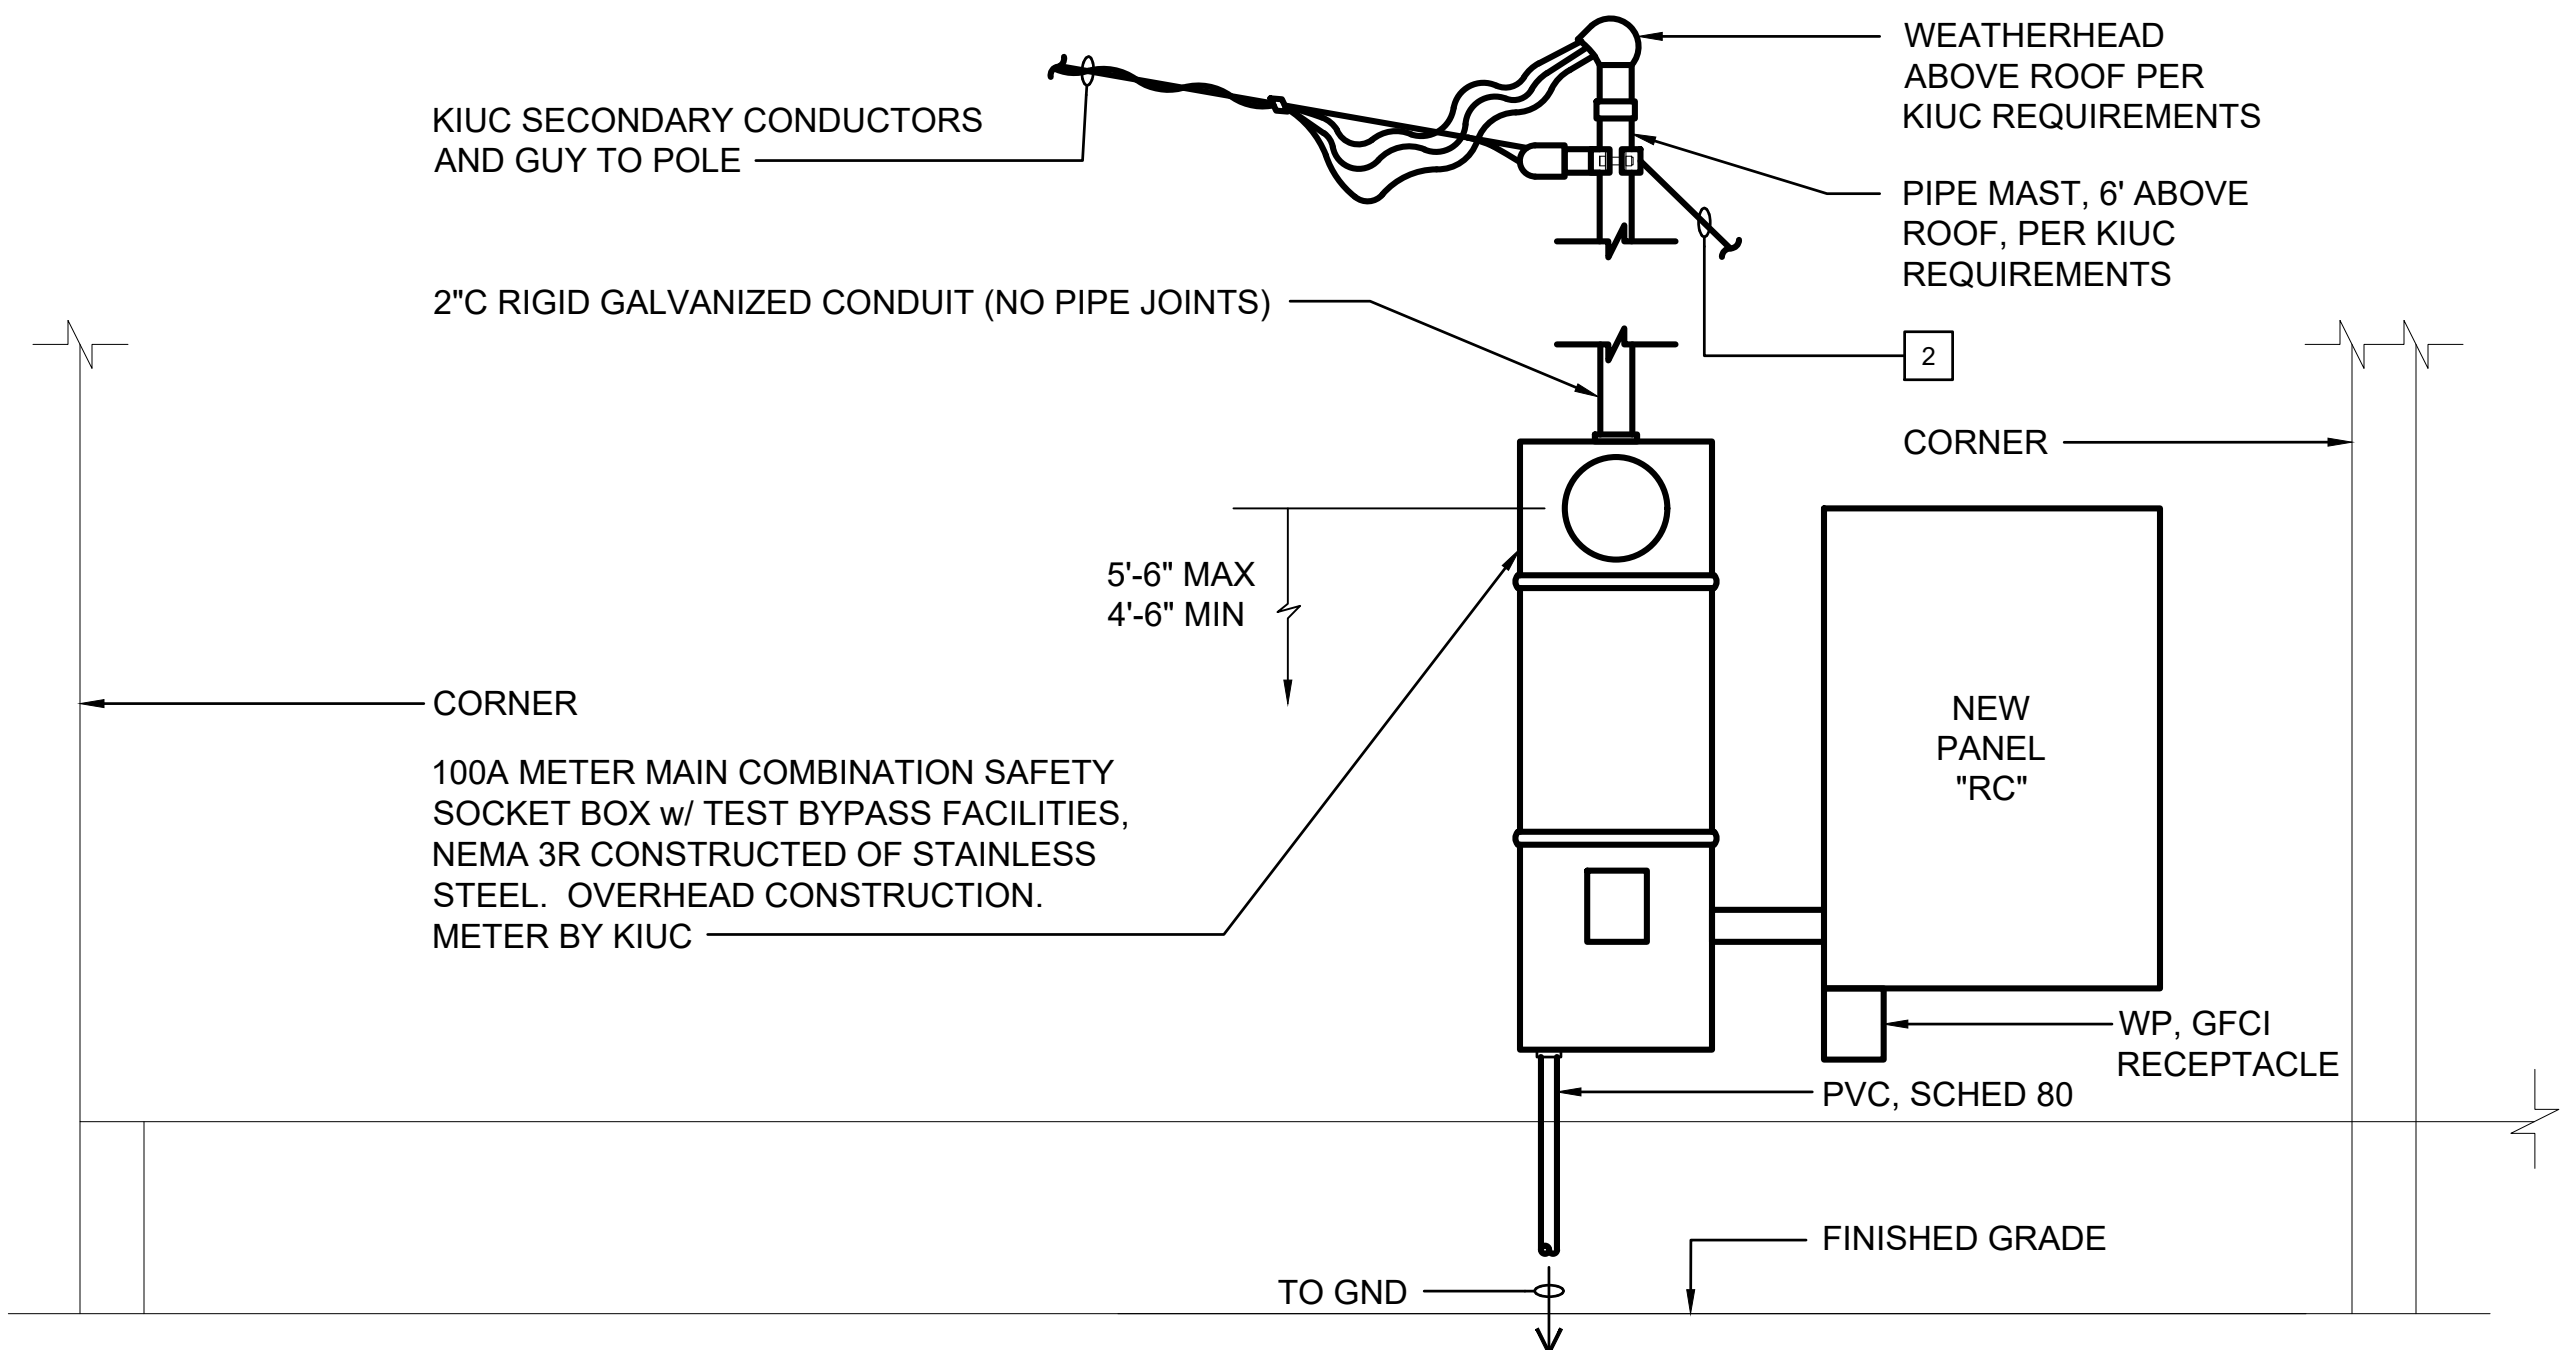


3 METER/SERVICE ENTRANCE ELEVATION - RANGER'S COTTAGE

 SCALE: 1" = 1'-0"



NOTES:

1. LIGHT LINES DENOTE EXISTING CONDITION
BOLD LINES DENOTE NEW WORK
"/" DENOTES REMOVAL WORK
- 2 GUY TO ROOF. SEE KIUC DETAIL 2
E-202 FOR ADDITIONAL INFORMATION.

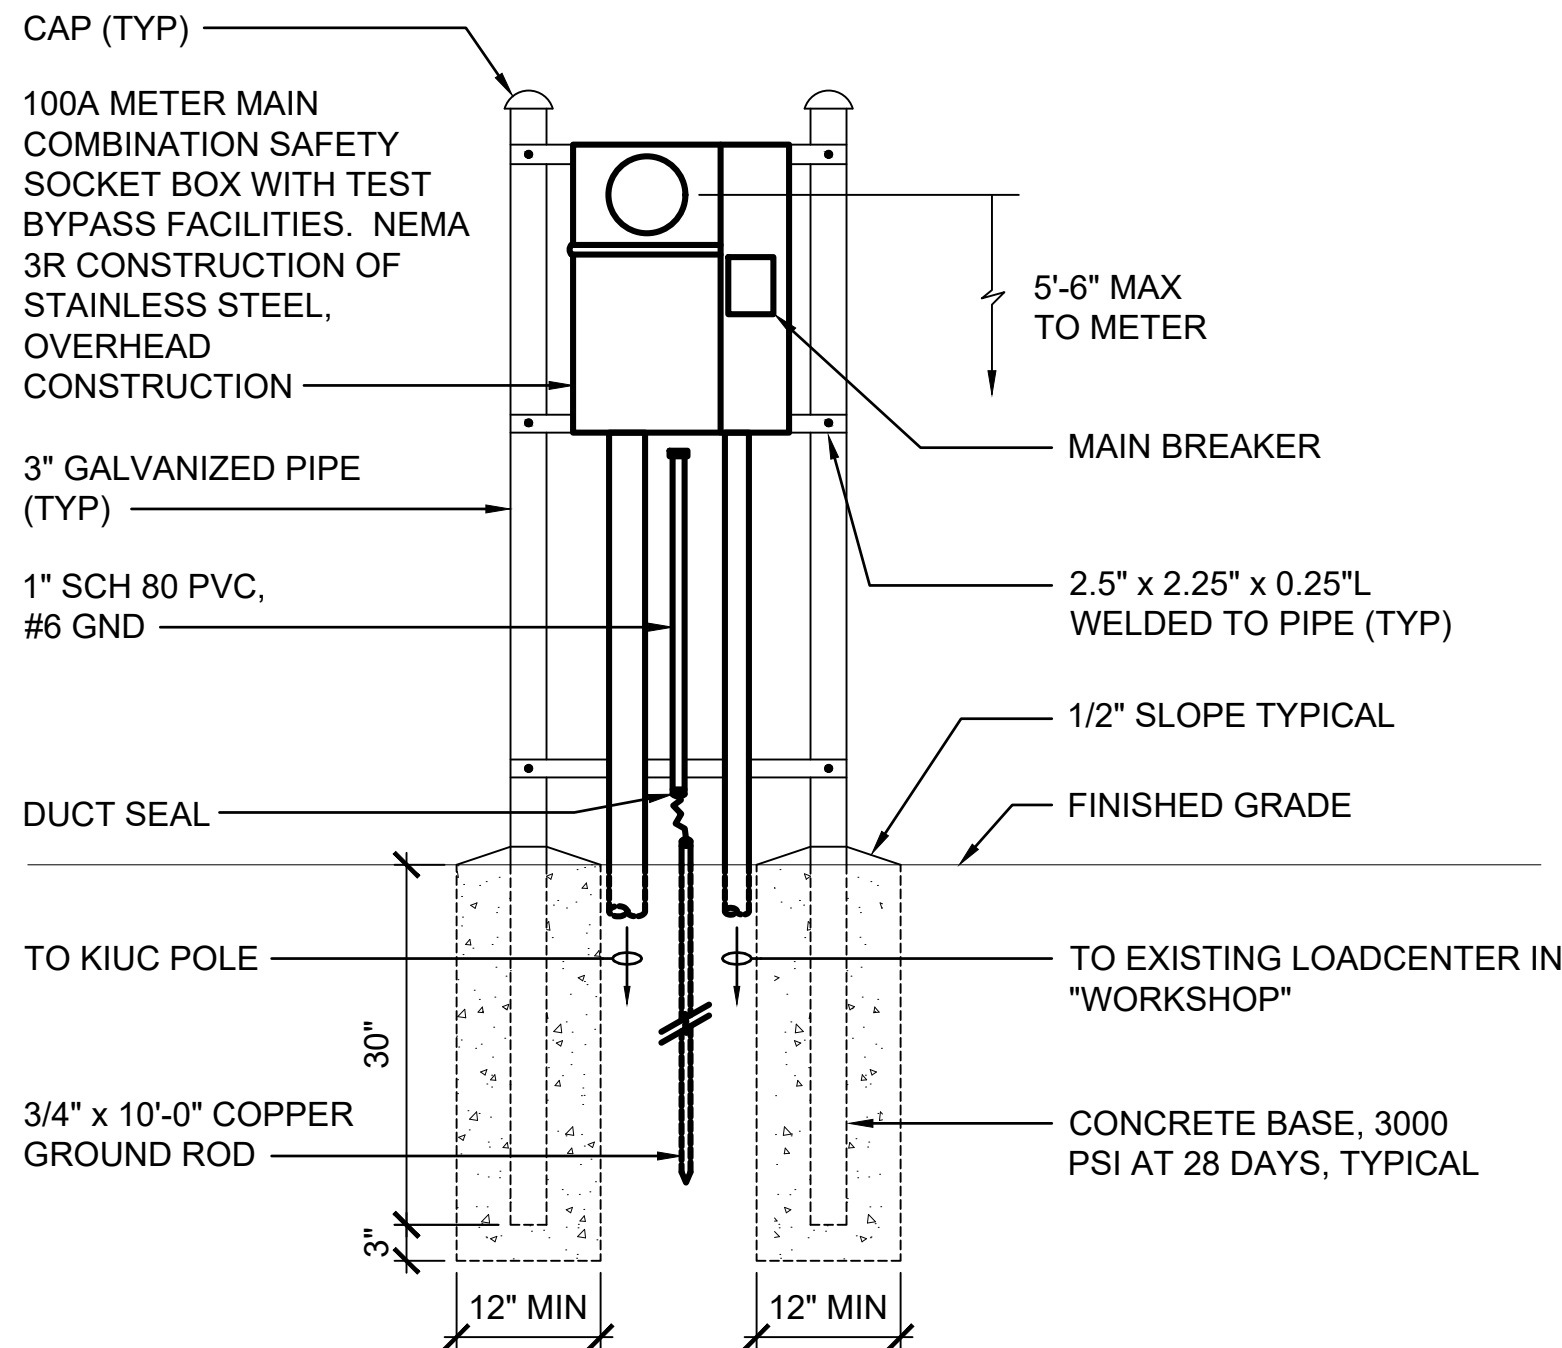

2 METER/SERVICE ENTRANCE ELEVATION - WORKSHOP

SCALE: NTS

NOTES:

1. PEDESTAL SHALL BE HOT DIPPED GALVANIZED AFTER FABRICATION.
2. ALL FASTENING BOLTS, NUTS, AND WASHERS SHALL BE STAINLESS STEEL.
3. SERVICE EQUIPMENT SHALL BE INSTALLED IN ACCORDANCE WITH KIUC REQUIREMENTS.
4. PROVIDE A MINIMUM OF 4 FEET OF CLEAR AND LEVEL WORKSPACE CLEARANCE IN FRONT OF METERING AND SERVICE EQUIPMENT.
5. PROVIDE PLASTIC METER SOCKET COVER AND BAND FOR ALL BLANK METER SOCKETS. LABEL PLASTIC COVER WITH CONTRACTOR'S NAME AND NUMBER SO COVER CAN BE RETURNED AFTER METER INSTALLATION.
6. PROVIDE A PERMANENT PHENOLIC NAMEPLATE (BLACK WITH WHITE LETTERS) FOR ALL METER SOCKETS TO IDENTIFY THE ADDRESS, UNIT, SPACE, AREA OR LOAD SERVED (E.G. "WORKSHOP").
7. THE GROUNDING ELECTRODE CONDUCTOR SHALL NOT PASS THROUGH KIUC'S SEALABLE SECTIONS OR COMPARTMENTS.

REVISION NO.	SYM.	DESCRIPTION	SHT./OF	DATE	APPROVED
AARON C. HAMADA LICENSED PROFESSIONAL ENGINEER No. 8327-E HAWAII, U.S.A. #24002 MK ENGINEERS, LTD. LICENSE EXPIRATION DATE: 4/30/28 This work was prepared by me or under my supervision and construction of this project will be under my observation. Observation of construction is defined in Section 16-115-2 of the Hawaii Administrative Rules of the Board of Professional Engineers, Architects, Surveyors and Landscape Architects of the State of Hawaii (dated 9/13/01; effective 10/28/01) 4/29/2026 Dina Lau Civil Engineer STATE OF HAWAII DEPARTMENT OF LAND AND NATURAL RESOURCES ENGINEERING DIVISION KOKE'E STATE PARK ELECTRICAL IMPROVEMENTS WAIMEA, KAUAI, HAWAII METERING ELEVATION - 1 FUKUNAGA AND ASSOCIATES, INC DESIGNED: ACH DRAWN: MKE CHECKED: ACH APPROVED: Dina Lau CHIEF ENGINEER SUBMITTED: DATE: APRIL 2026 SCALE: AS SHOWN DRAWING NO. E-201					





1. LIGHT LINES DENOTE EXISTING CONDITION
 BOLD LINES DENOTE NEW WORK
 "/" DENOTES REMOVAL WORK

2
E-202



1. VERIFY REQUIREMENTS WITH KIUC.
2. THIS DIAGRAM IS INTENDED TO SHOW KIUC REQUIREMENTS FOR GUY MASTS, IN ACCORDANCE WITH N.E.C. SEC. 230.28.
3. FOR ALL TYPES OF SINGLE STORY ROOFING: "H" = 5 FEET.

JOB NO. F46C602F SHEET NO. 13 OF 21 SHEETS

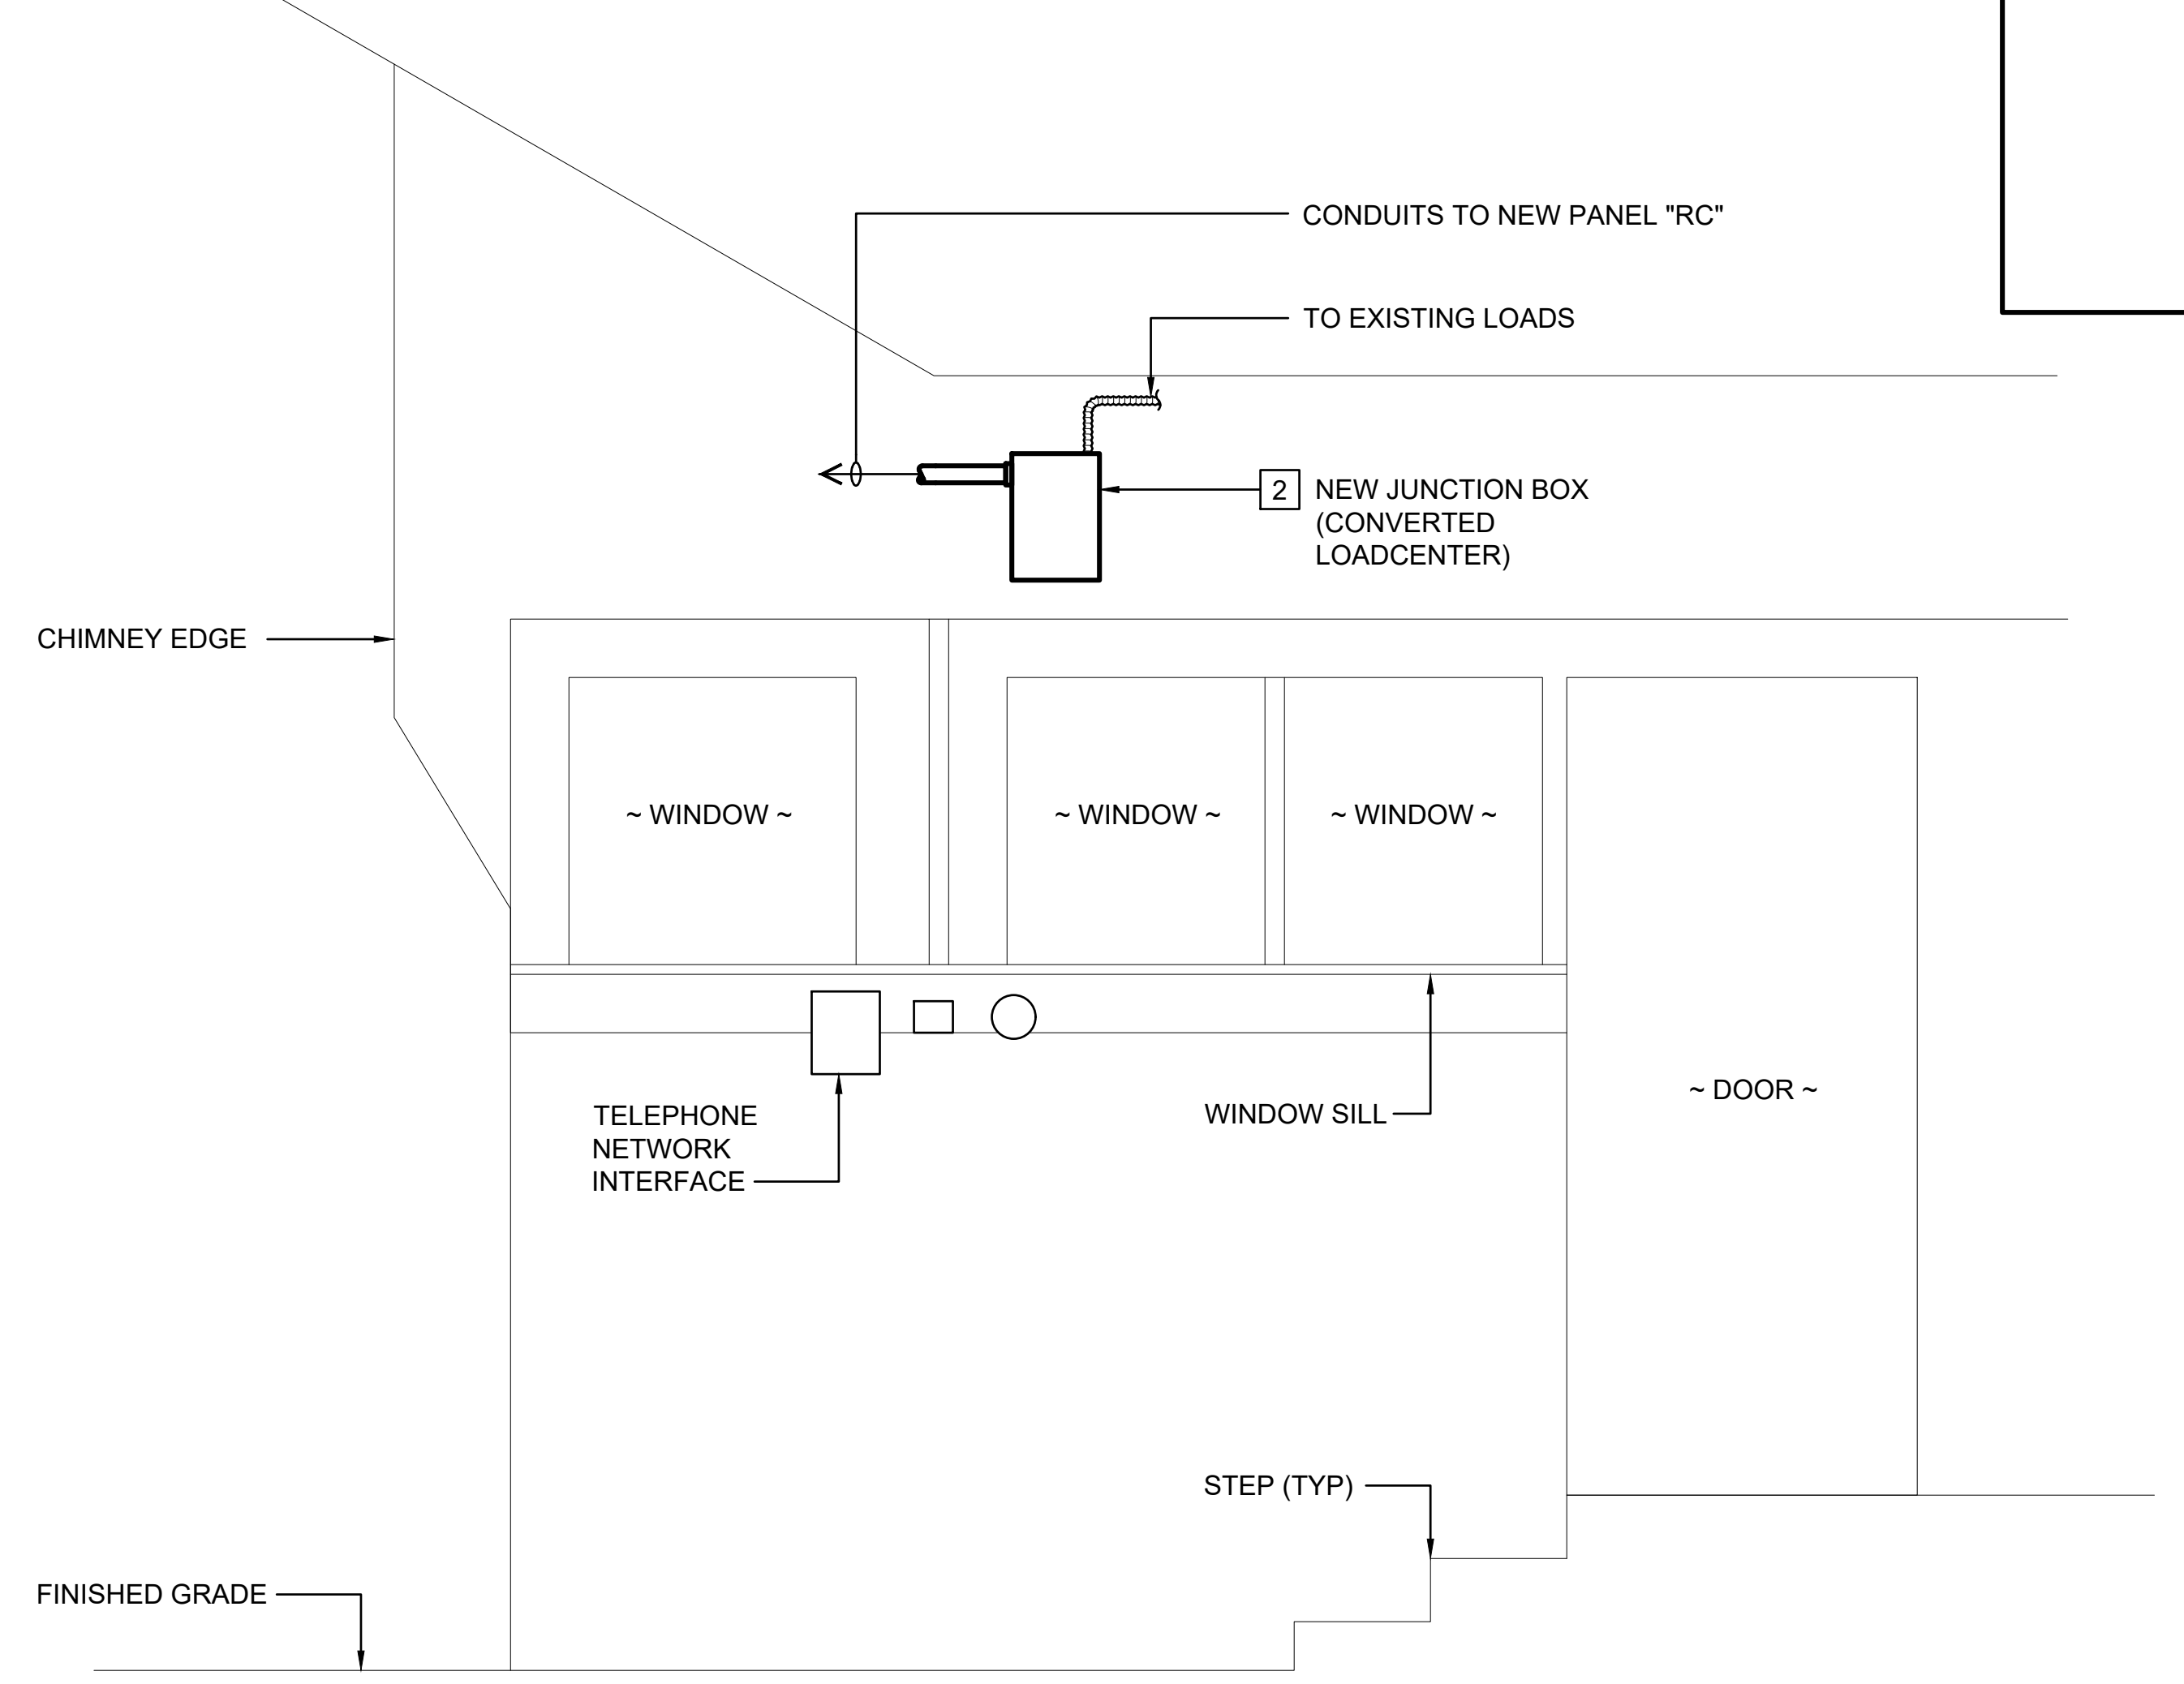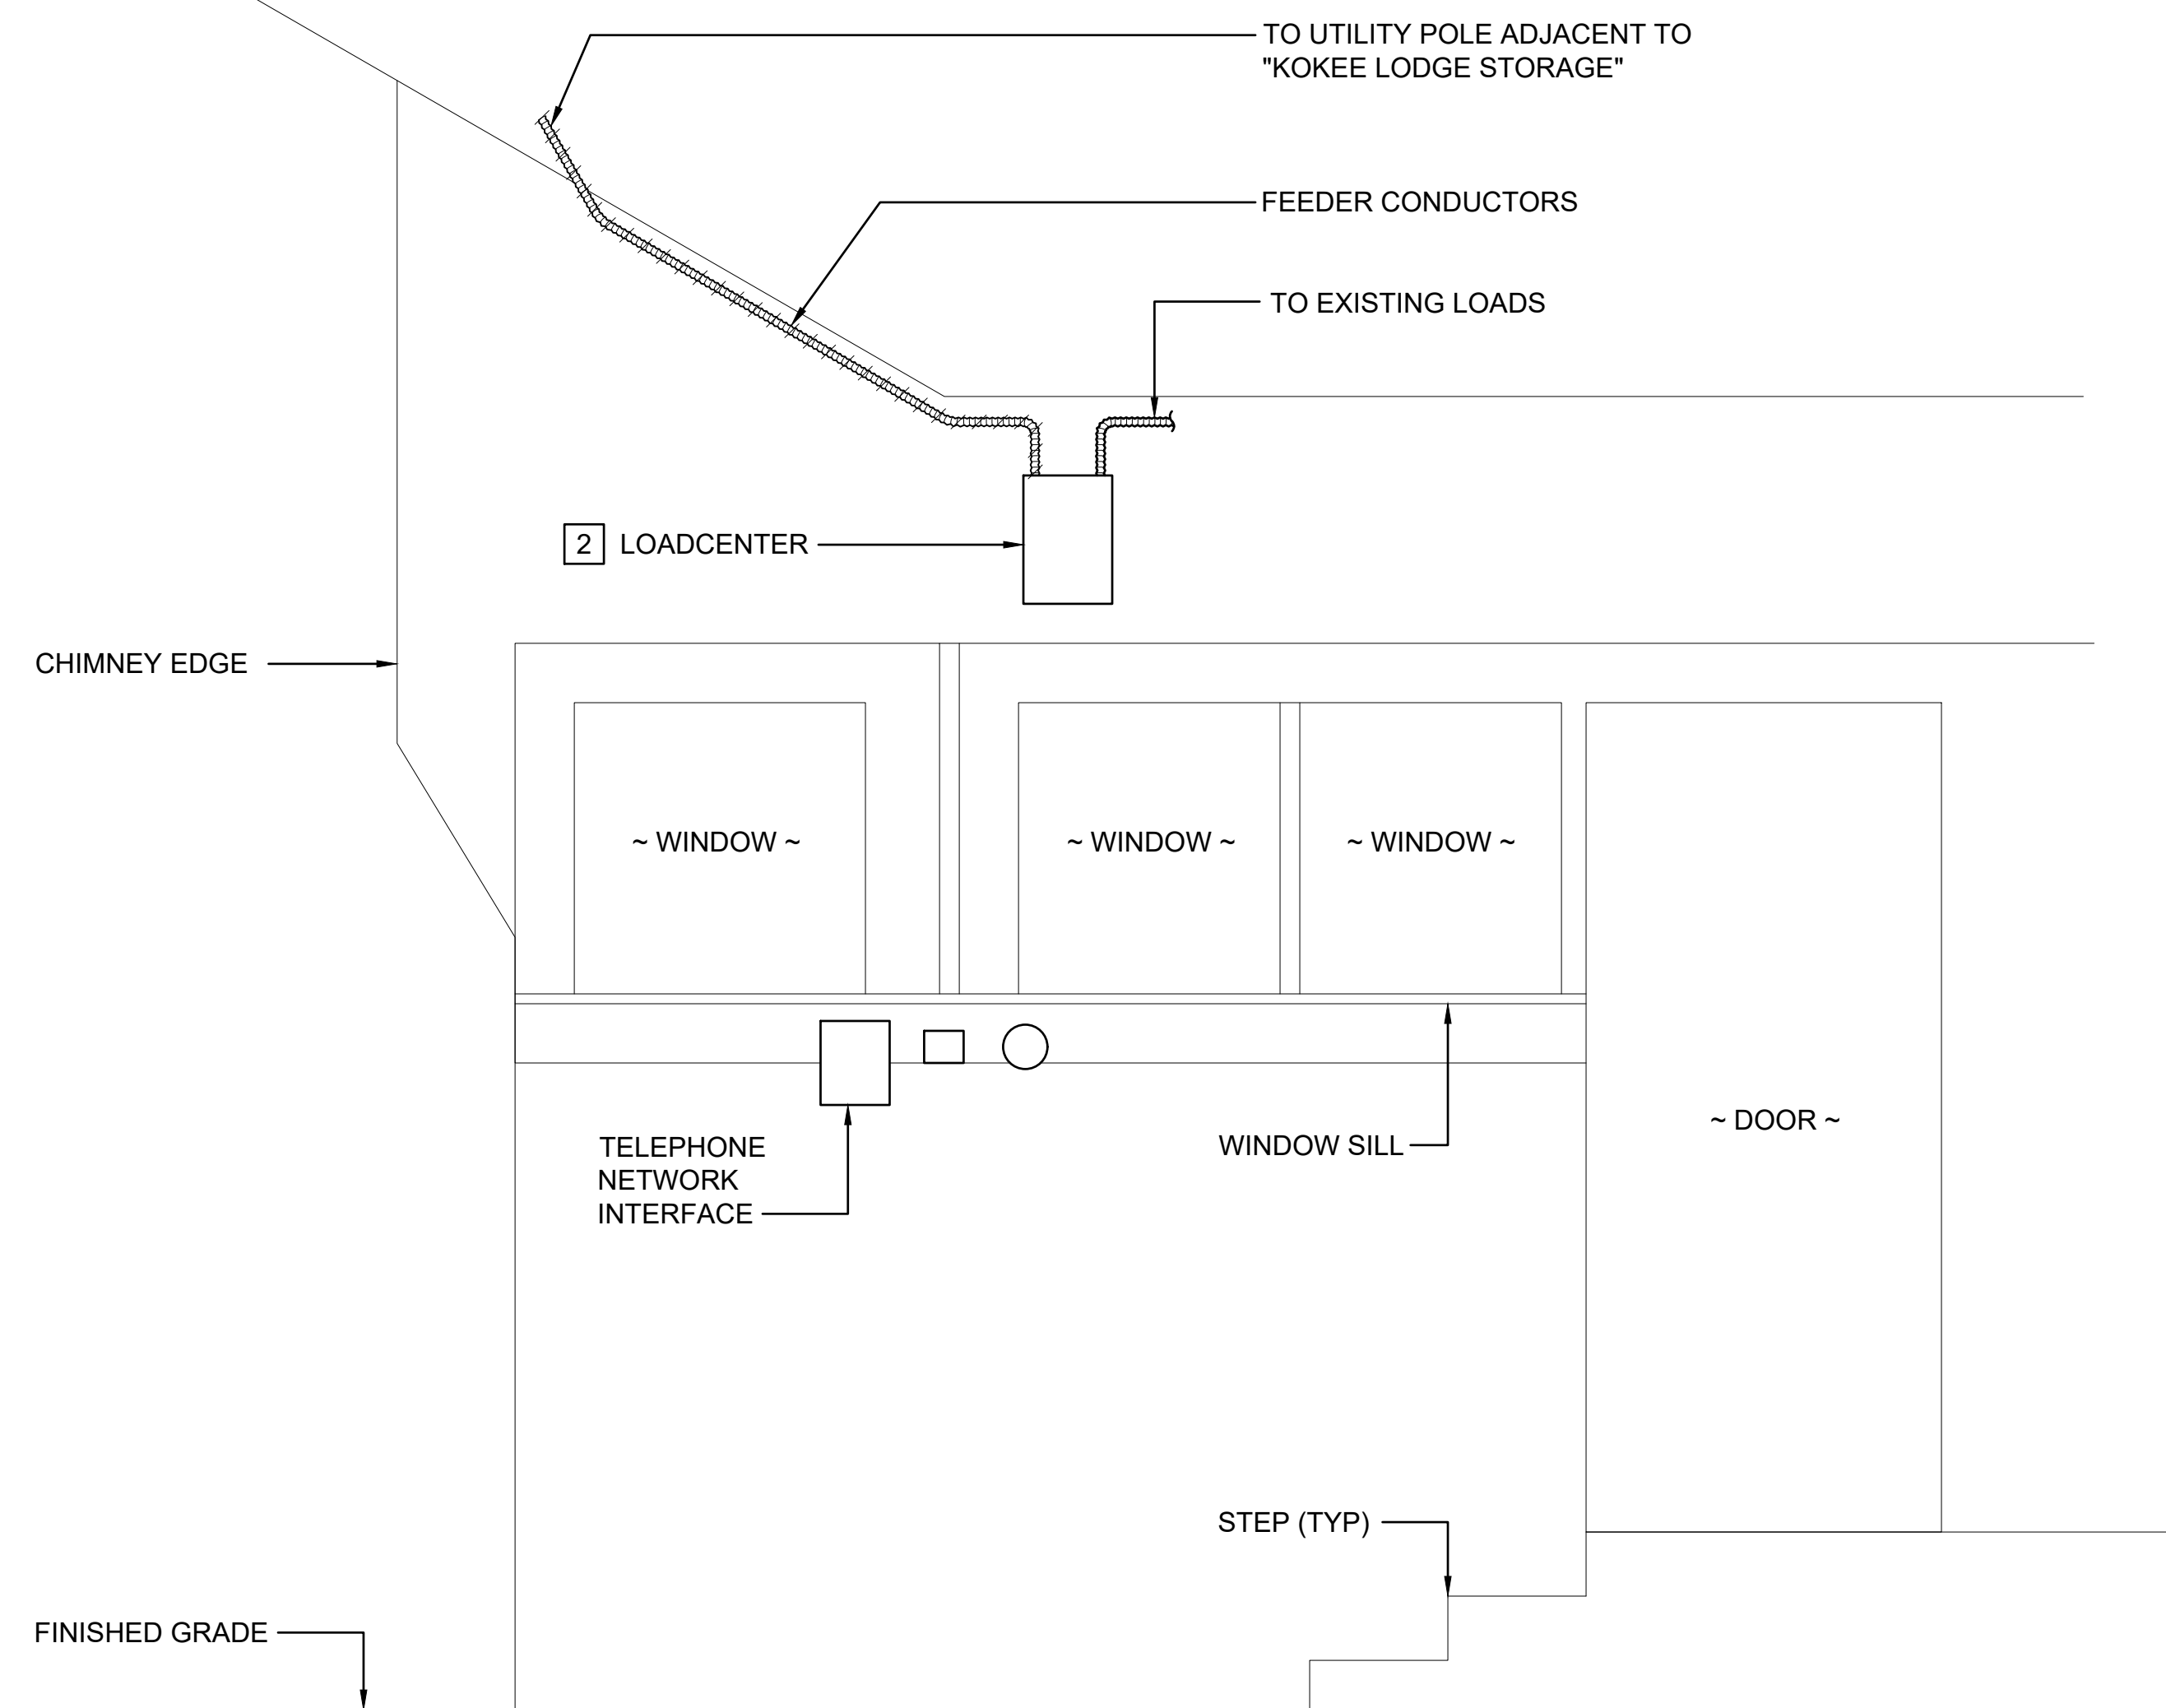


1 RANGER'S COTTAGE EQUIPMENT ELEVATION - DEMO

SCALE: 3/4" = 1'-0"

NOTES:

1. ——— LIGHT LINES DENOTE EXISTING CONDITION
 // // // // // "I" DENOTES REMOVAL WORK

 - 2 CONVERT TO A JUNCTION BOX. REMOVE SURFACE RUST AND PAINT ENCLOSURE. PROVIDE NEW COVER.



2 RANGER'S COTTAGE EQUIPMENT ELEVATION

 
SCALE: 3/4" = 1'-0"

NOTES:


1. ——— LIGHT LINES DENOTE EXISTING CONDITION
 ——— BOLD LINES DENOTE NEW WORK

- 2 CONVERT EXISTING LOADCENTER INTO JUNCTION BOX AND PRESERVE BRANCH CIRCUIT CONDUCTORS FOR RECONNECTION. PROVIDE NEW COVER. REMOVE SURFACE RUST AND REPAINT ENCLOSURE.

3. PROVIDE JUNCTION BOXES AS NEEDED TO LIMIT CONDUIT RUN TO NO MORE THAN (3) 90 DEGREE BENDS.




REVISION NO.		SYM.	DESCRIPTION	SHT./OF	DATE	APPROVED
 #24002 WK. ENGINEERS, LLC LICENSE EXPIRATION DATE: 4/30/28 This work was prepared by me or under my supervision and construction of this project will be under my observation. Observation of construction is defined in Section 18-115-2 of the Hawaii Administrative Rules of the Board of Professional Engineers, Architects, Surveyors and Landscape Architects of the State of Hawaii (dated 9/15/01; effective 10/26/01) <i>Aaron Hamada</i> 4/29/06			STATE OF HAWAII DEPARTMENT OF LAND AND NATURAL RESOURCES ENGINEERING DIVISION			
			KOKE'E STATE PARK ELECTRICAL IMPROVEMENTS WAIMEA, KAUAI, HAWAII			
			RANGER'S COTTAGE ELEVATIONS			
			FUKUNAGA AND ASSOCIATES, INC			
			DESIGNED: ACH		SUBMITTED:	
DRAWN: MKE		DATE: APRIL 2026				
CHECKED: ACH <i>ac</i>		SCALE: AS SHOWN				
APPROVED: Dina Lau E-signed 2026-05-07 07:15AM HST dina.u.lau@hawaii.gov State of Hawaii		 DINA LAU				
CHIEF ENGINEER		DRAWING NO. E-203				

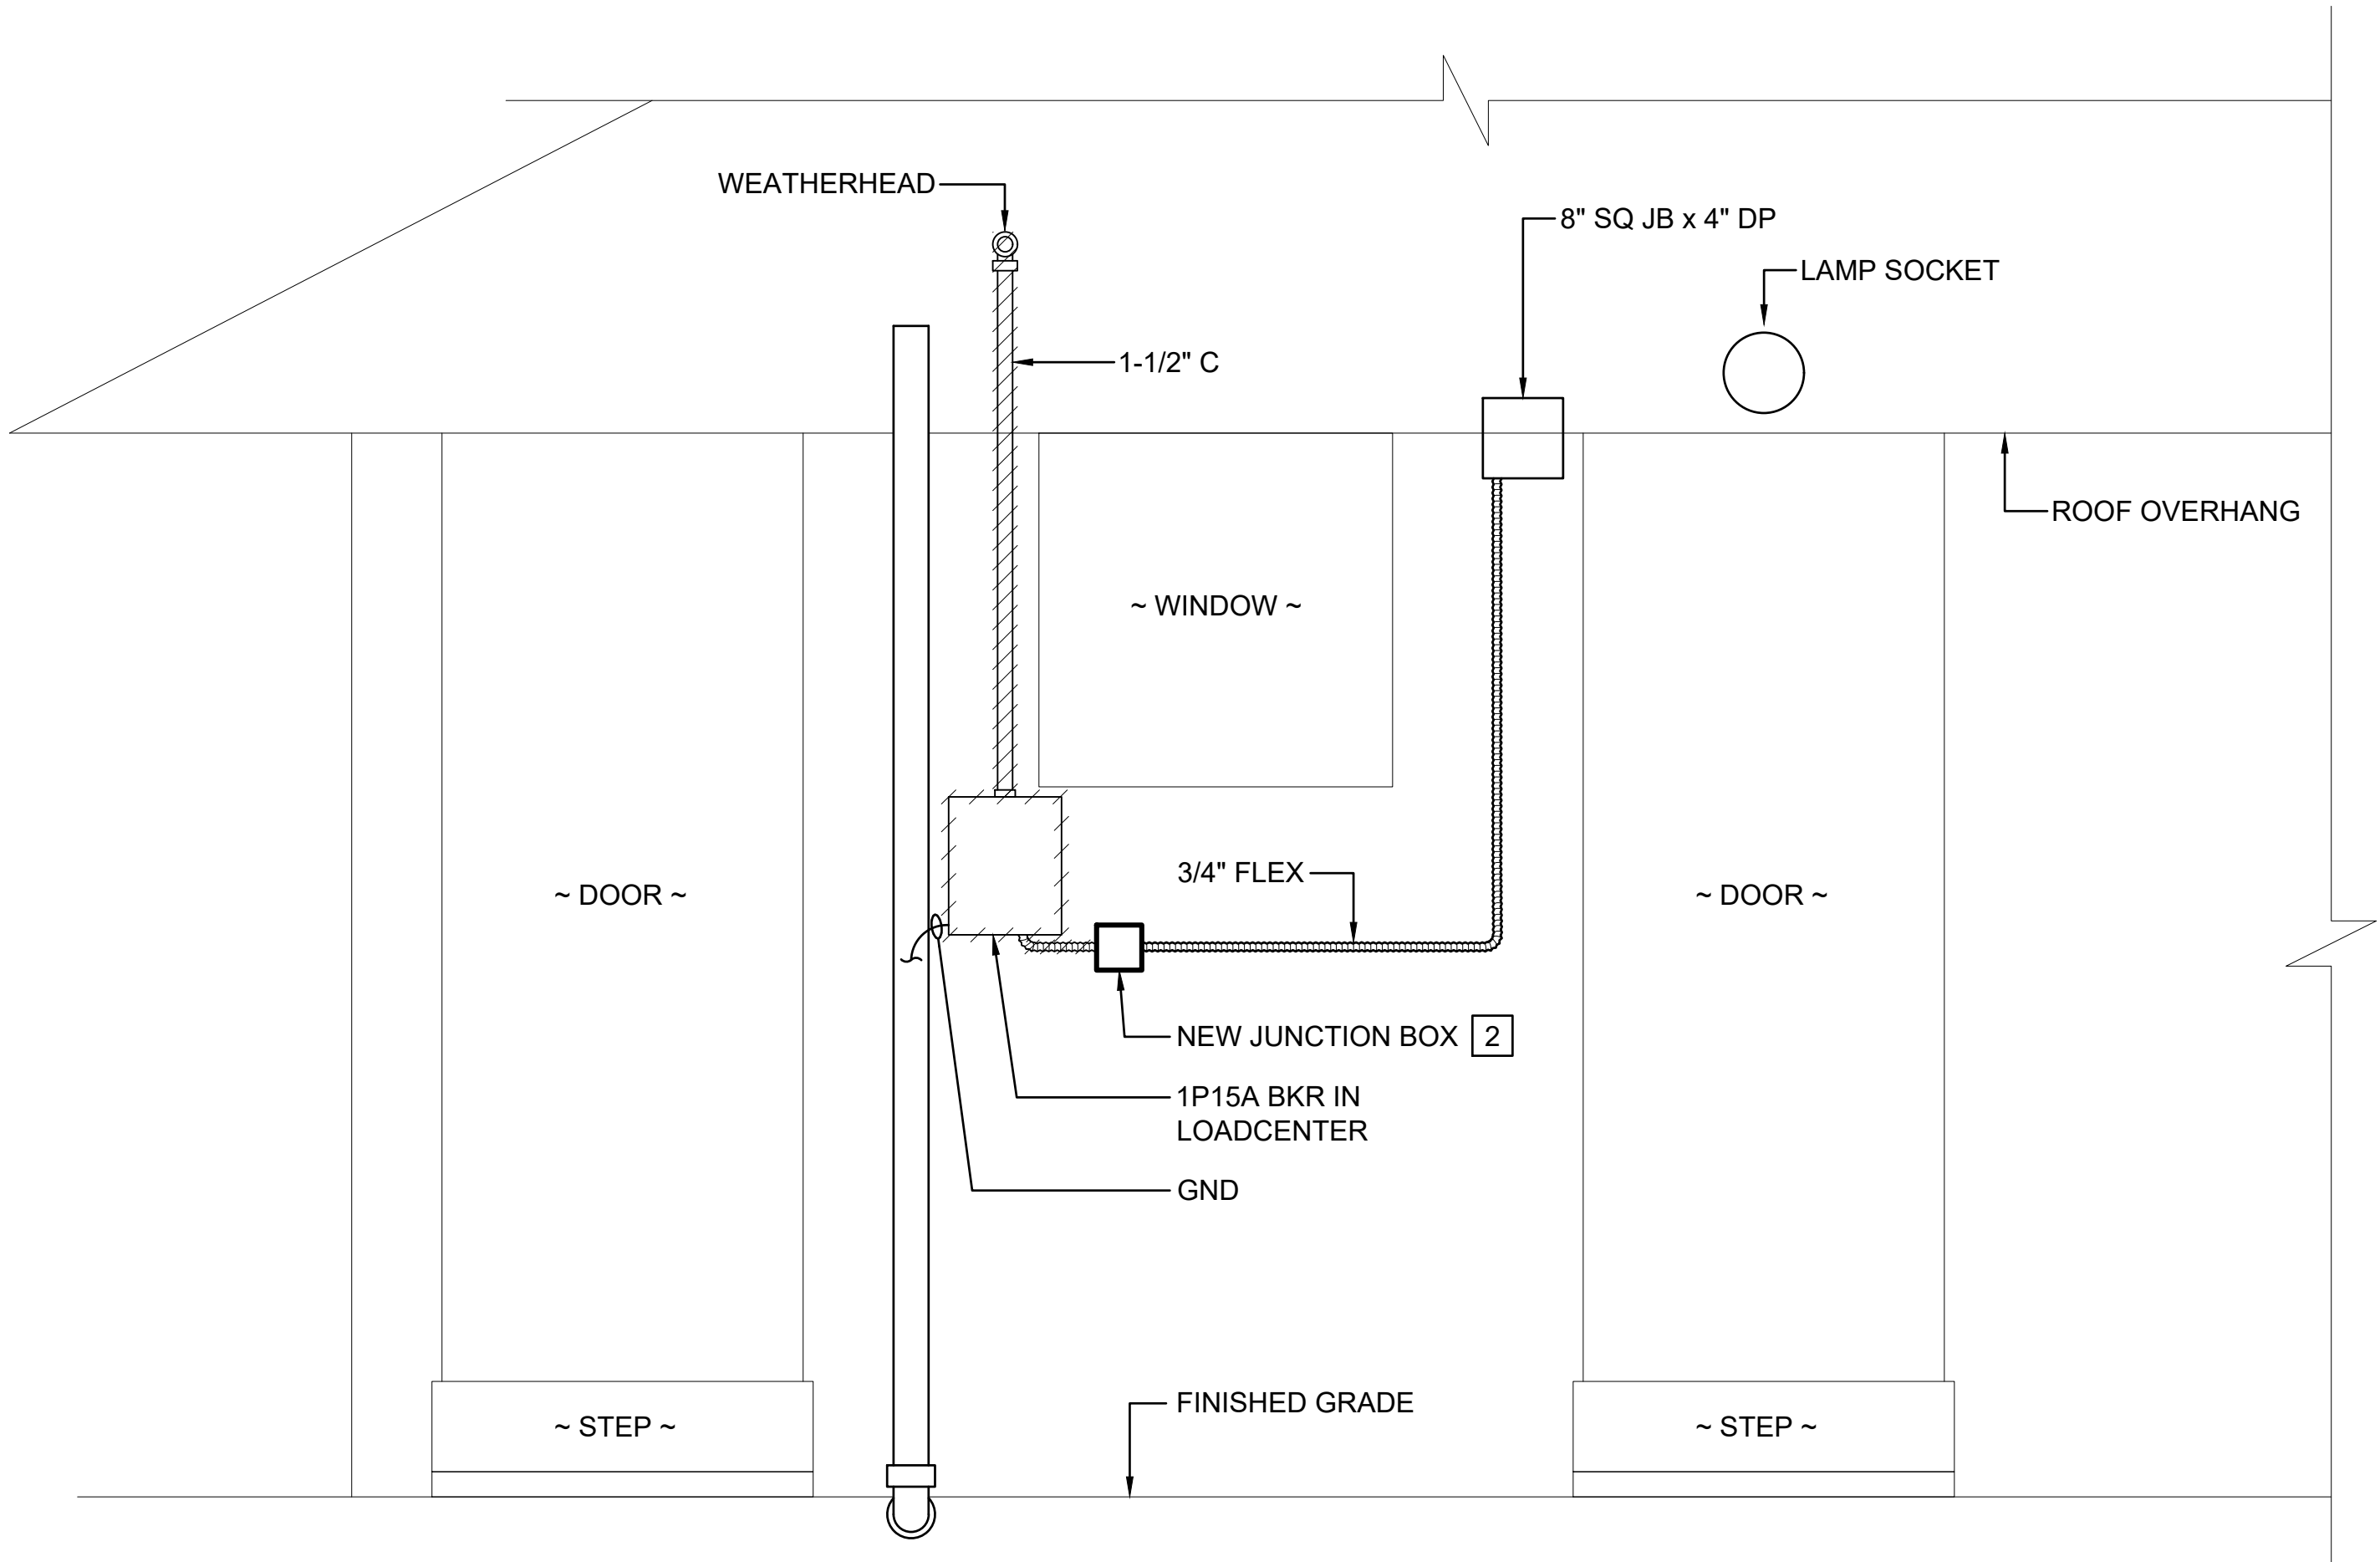

1 PARK HQ EQUIPMENT ELEVATION - DEMO

 
SCALE: 3/4" = 1'-0"



NOTES:


1. ——— LIGHT LINES DENOTE EXISTING CONDITION
———— BOLD LINES DENOTE NEW WORK
//////// "I" DENOTES REMOVAL WORK

2 PROVIDE NEW JUNCTION BOX TO INTERCEPT EXISTING BRANCH CIRCUIT CONDUIT AND CONDUCTORS. PRESERVE CONDUCTORS FOR RECONNECTION.

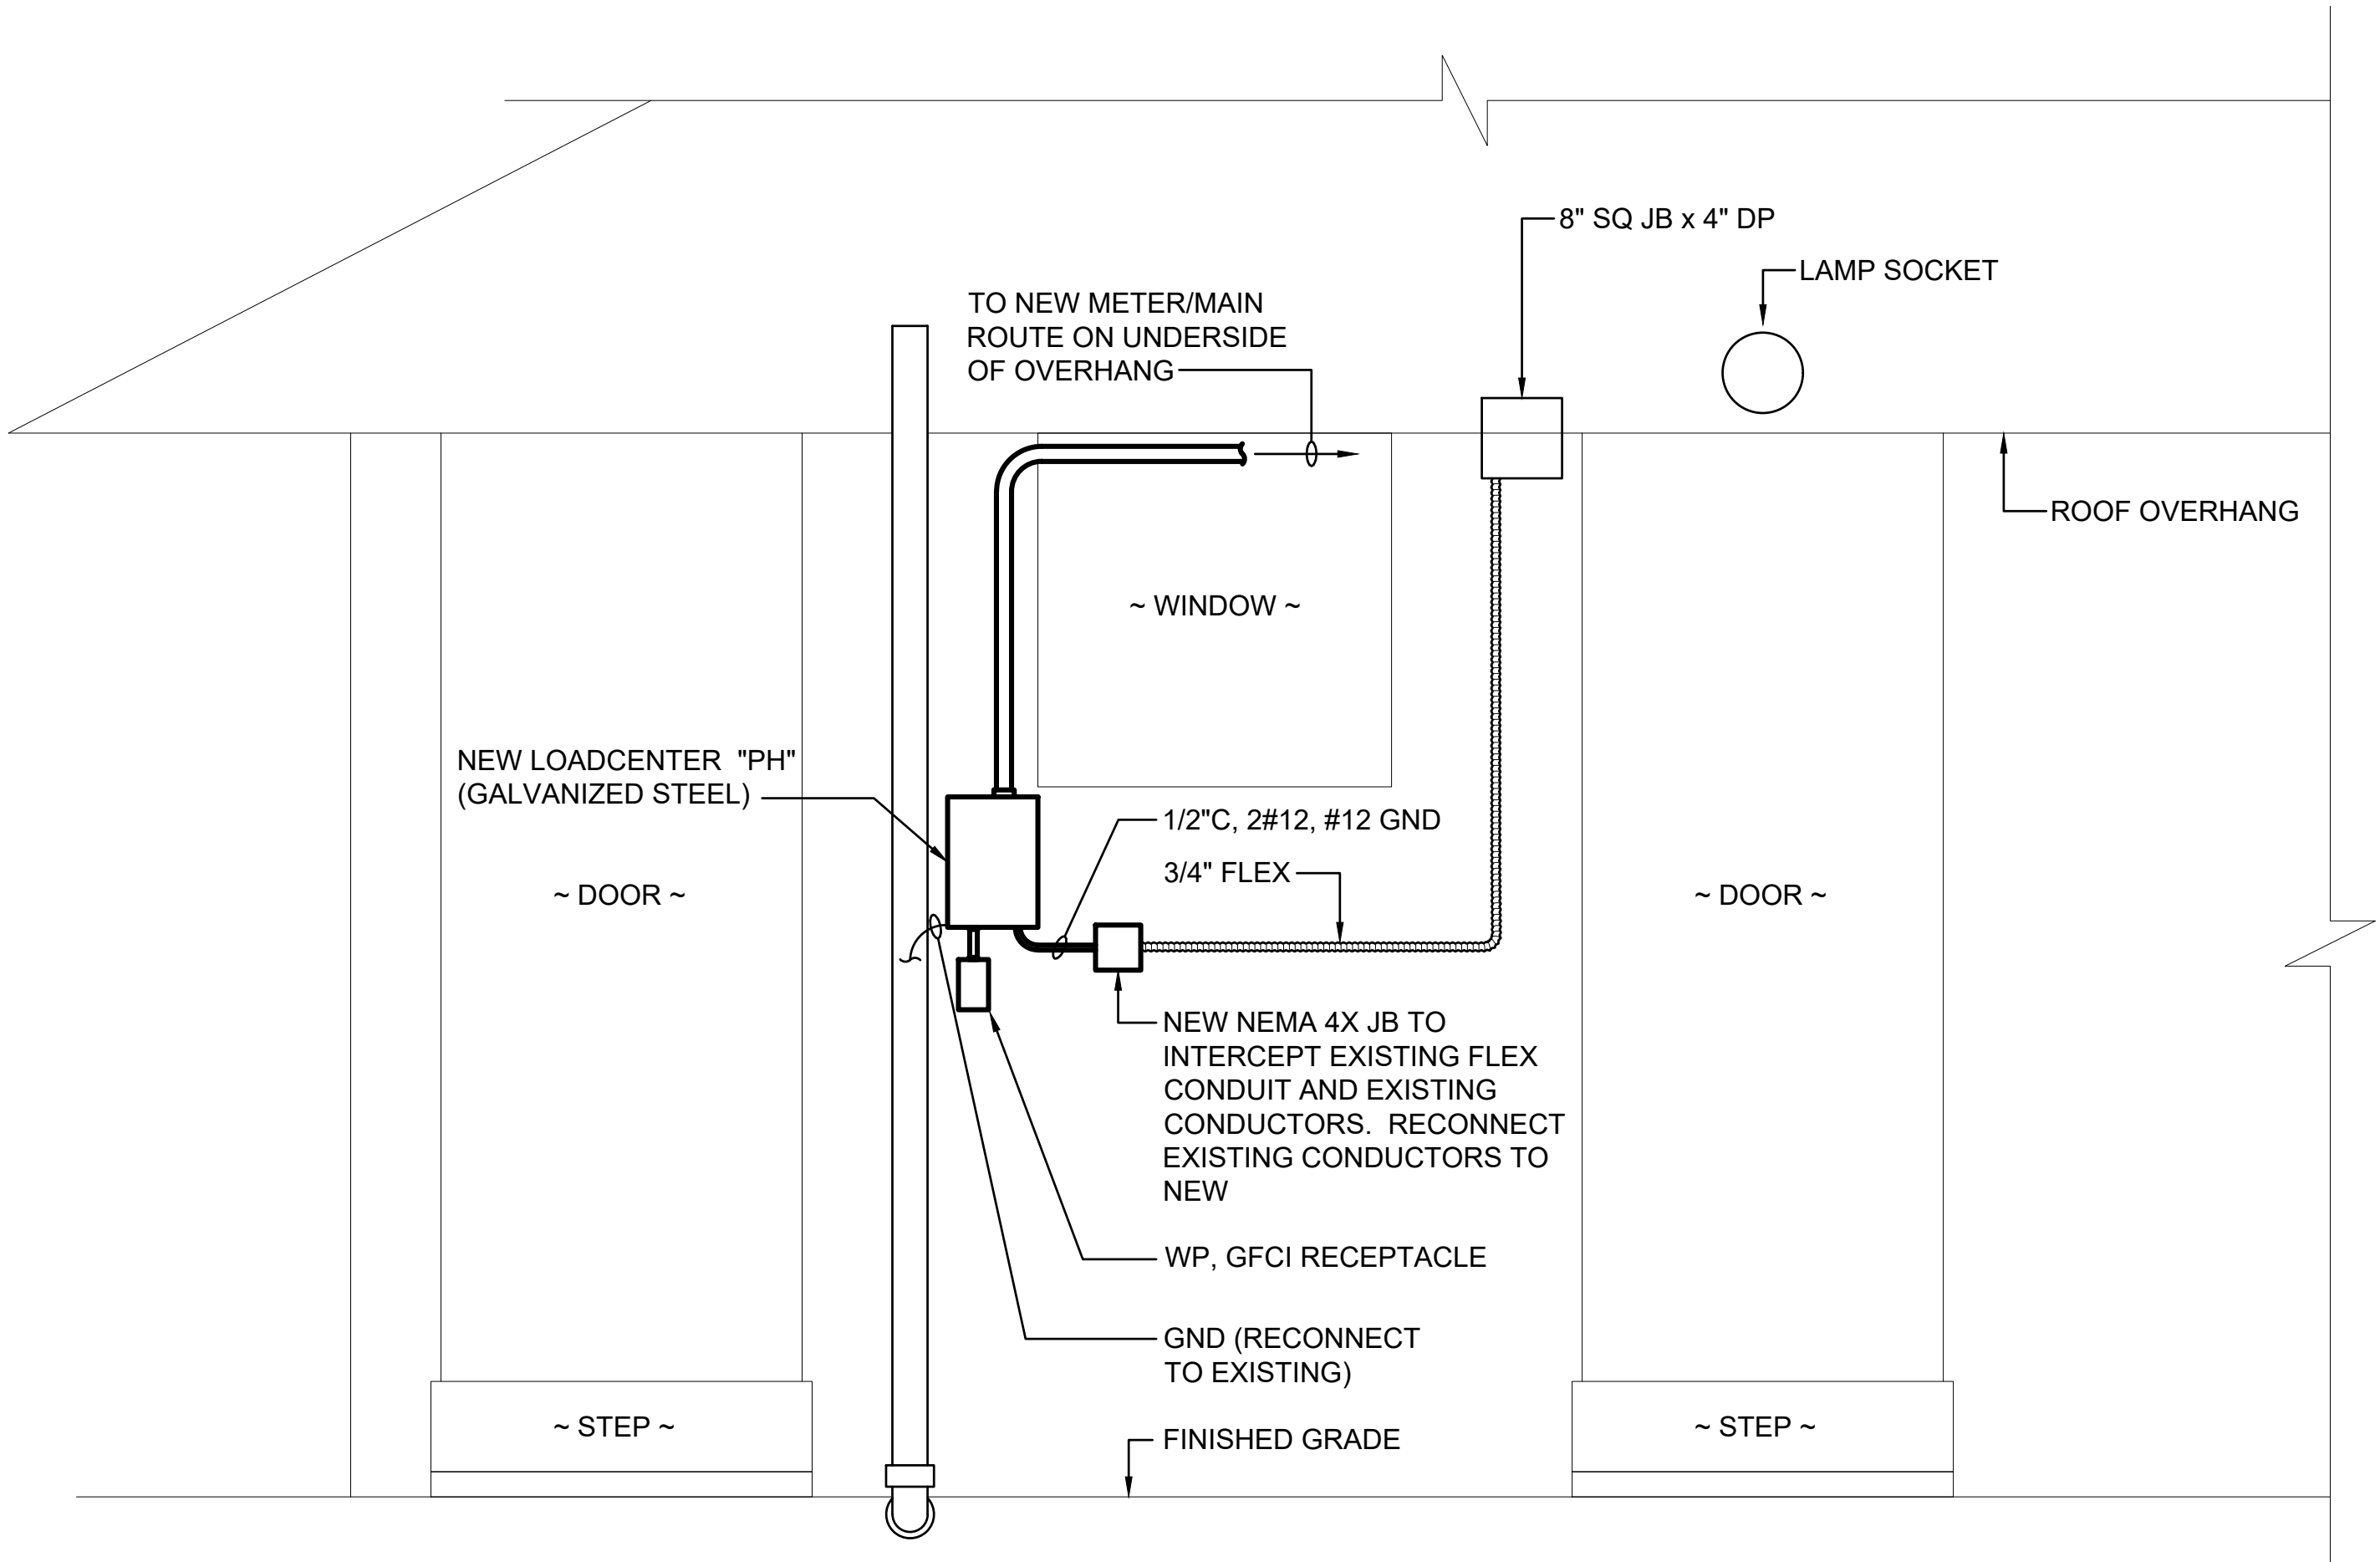

2 PARK HQ EQUIPMENT ELEVATION

 
SCALE: 3/4" = 1'-0"



NOTES:


1. ——— LIGHT LINES DENOTE EXISTING CONDITION
———— BOLD LINES DENOTE NEW WORK

REVISION NO.	SYM.	DESCRIPTION	SHT./OF	DATE	APPROVED
		STATE OF HAWAII DEPARTMENT OF LAND AND NATURAL RESOURCES ENGINEERING DIVISION			
		KOKE'E STATE PARK ELECTRICAL IMPROVEMENTS WAIMEA, KAUAI, HAWAII			
		PARK HEADQUARTERS ELEVATIONS			
		FUKUNAGA AND ASSOCIATES, INC			
DESIGNED: ACH		SUBMITTED:			
DRAWN: MKE		DATE: APRIL 2026			
CHECKED: ACH		SCALE: AS SHOWN		DRAWING NO.	
APPROVED: Dina Lau E-signed 2026-05-07 07:15AM HST dina.u.lau@hawaii.gov State of Hawaii Civil Engineer				E-204	

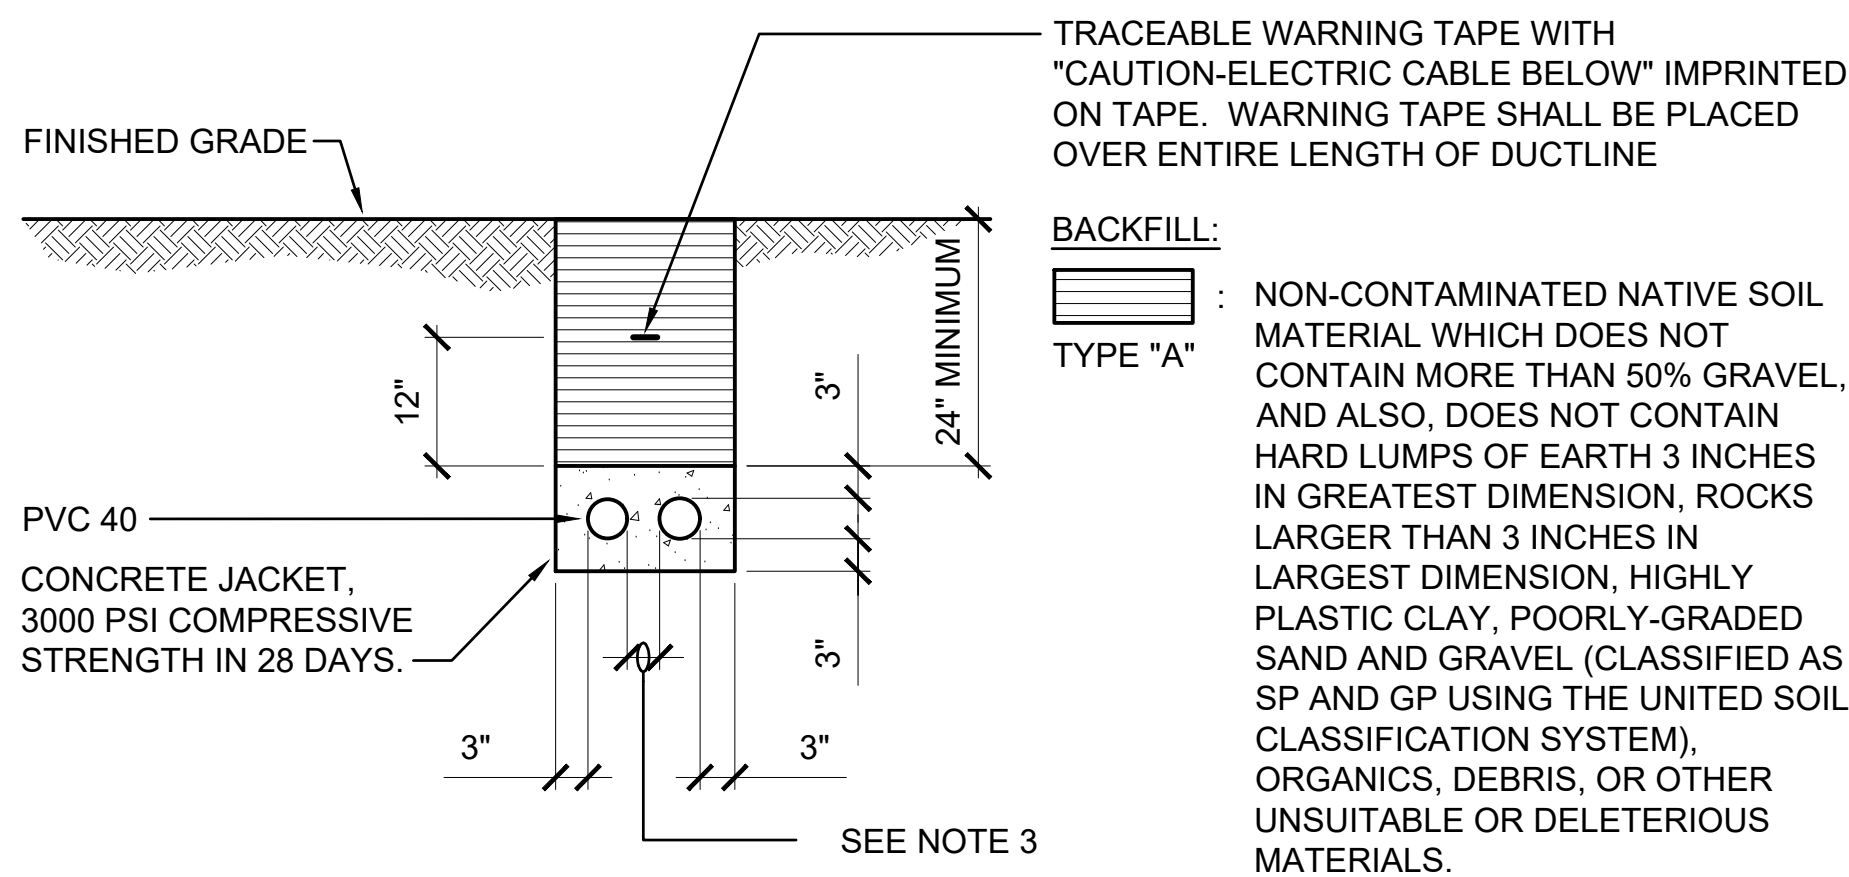


A TYPICAL DUCT SECTION (CONCRETE ENCASED)
SCALE: NTS

- NOTES:
- WHERE TRENCH ENCOUNTERS EXISTING CONCRETE OR ASPHALT CONCRETE, SURFACE SHALL BE SAWCUT. BACKFILL, COMPACT AND PATCH SURFACE TO MATCH ADJACENT AREA. SEE TRENCH RESTORATION DETAIL AND CONCRETE SIDEWALK RESTORATION DETAIL.
 - SEE DUCT SECTION DETAILS FOR CONDUIT ARRANGEMENT.
 - PROVIDE 3" SEPARATION BETWEEN DUCTS.

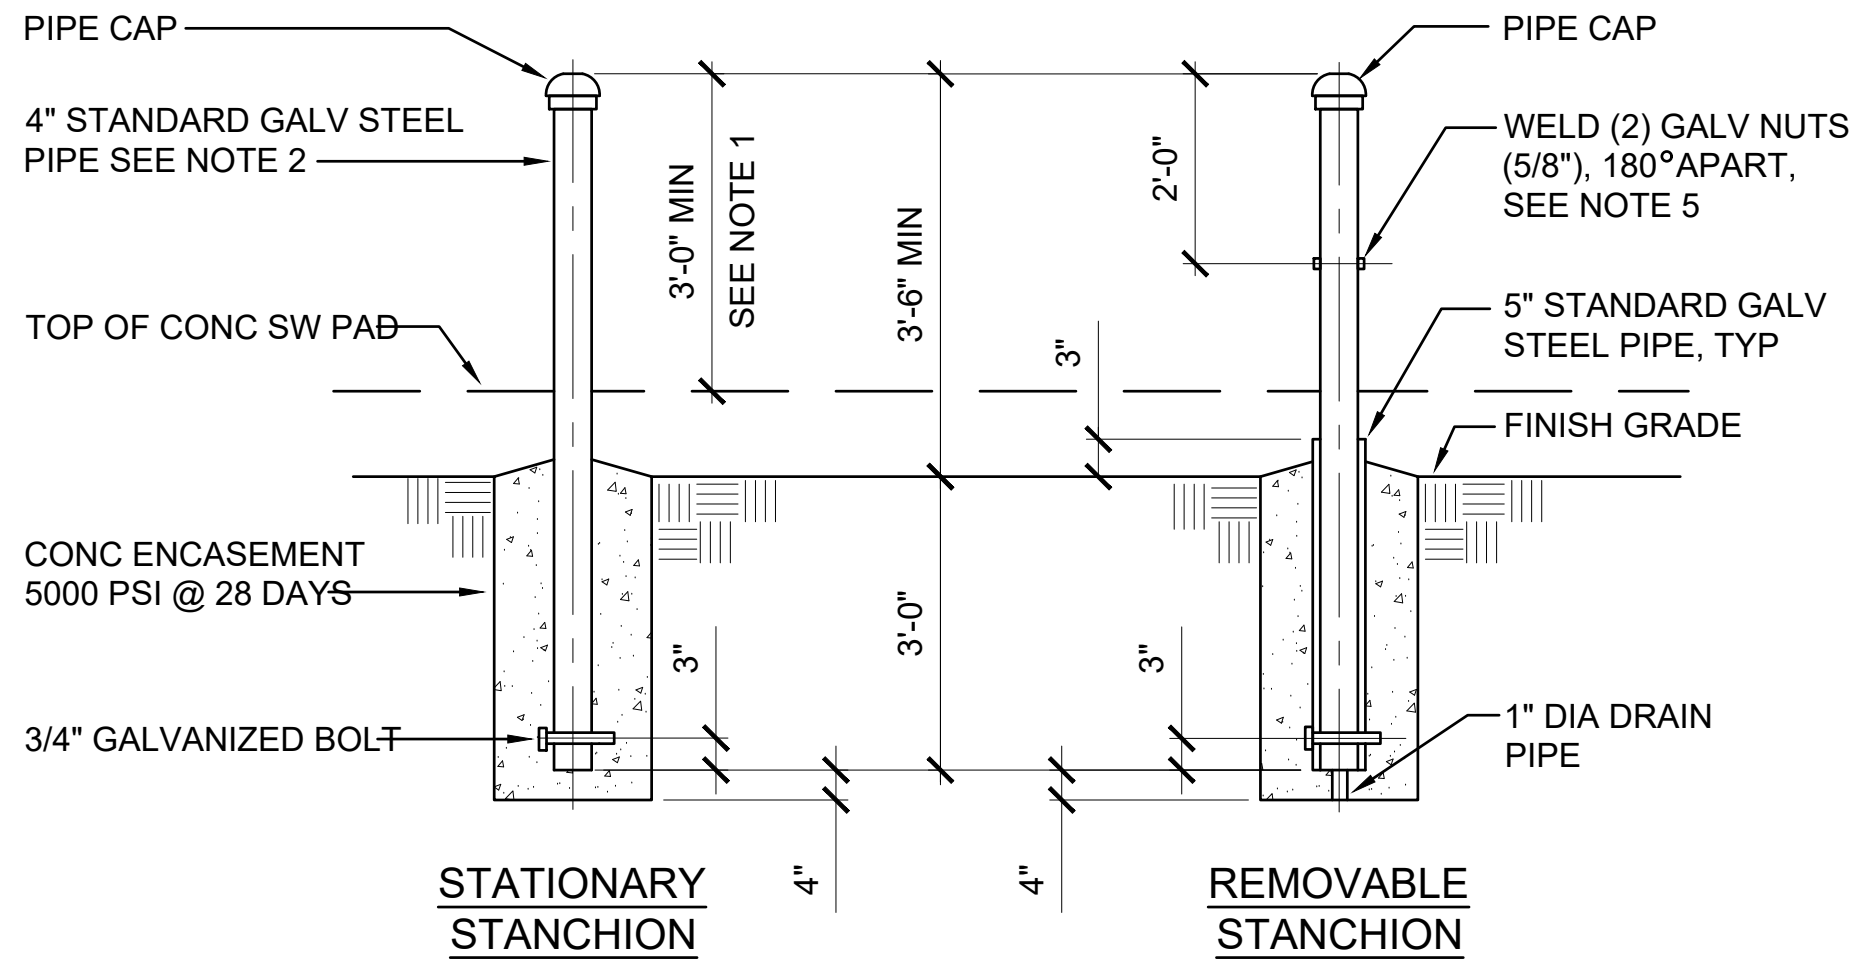


D STANCHION DETAIL
SCALE: NTS


- NOTES:
- ALL STANCHIONS SHALL BE INSTALLED AT THE SAME HEIGHT ABOVE GRADE.
 - STATIONARY STANCHIONS TO BE FILLED WITH CONCRETE TO WEIGH APPROXIMATELY 160 LBS.
 - WELDED NUTS ARE FOR SCREWING IN BOLTS TO ACT AS HANDLES FOR LIFTING REMOVABLE STANCHIONS. BOLT TO BE REMOVED AFTER INSTALLATION.
 - STANCHIONS SHALL BE PAINTED YELLOW PER ANSI SPEC. Z53.1 TO COMPLY WITH OSHA STANDARDS PER COLOR CODING.
 - STANCHION SHALL CONFORM TO ASTM A53.
 - STANCHION TYPE AND LOCATION SHALL REQUIRE APPROVAL FROM DEPARTMENT OF WATER.

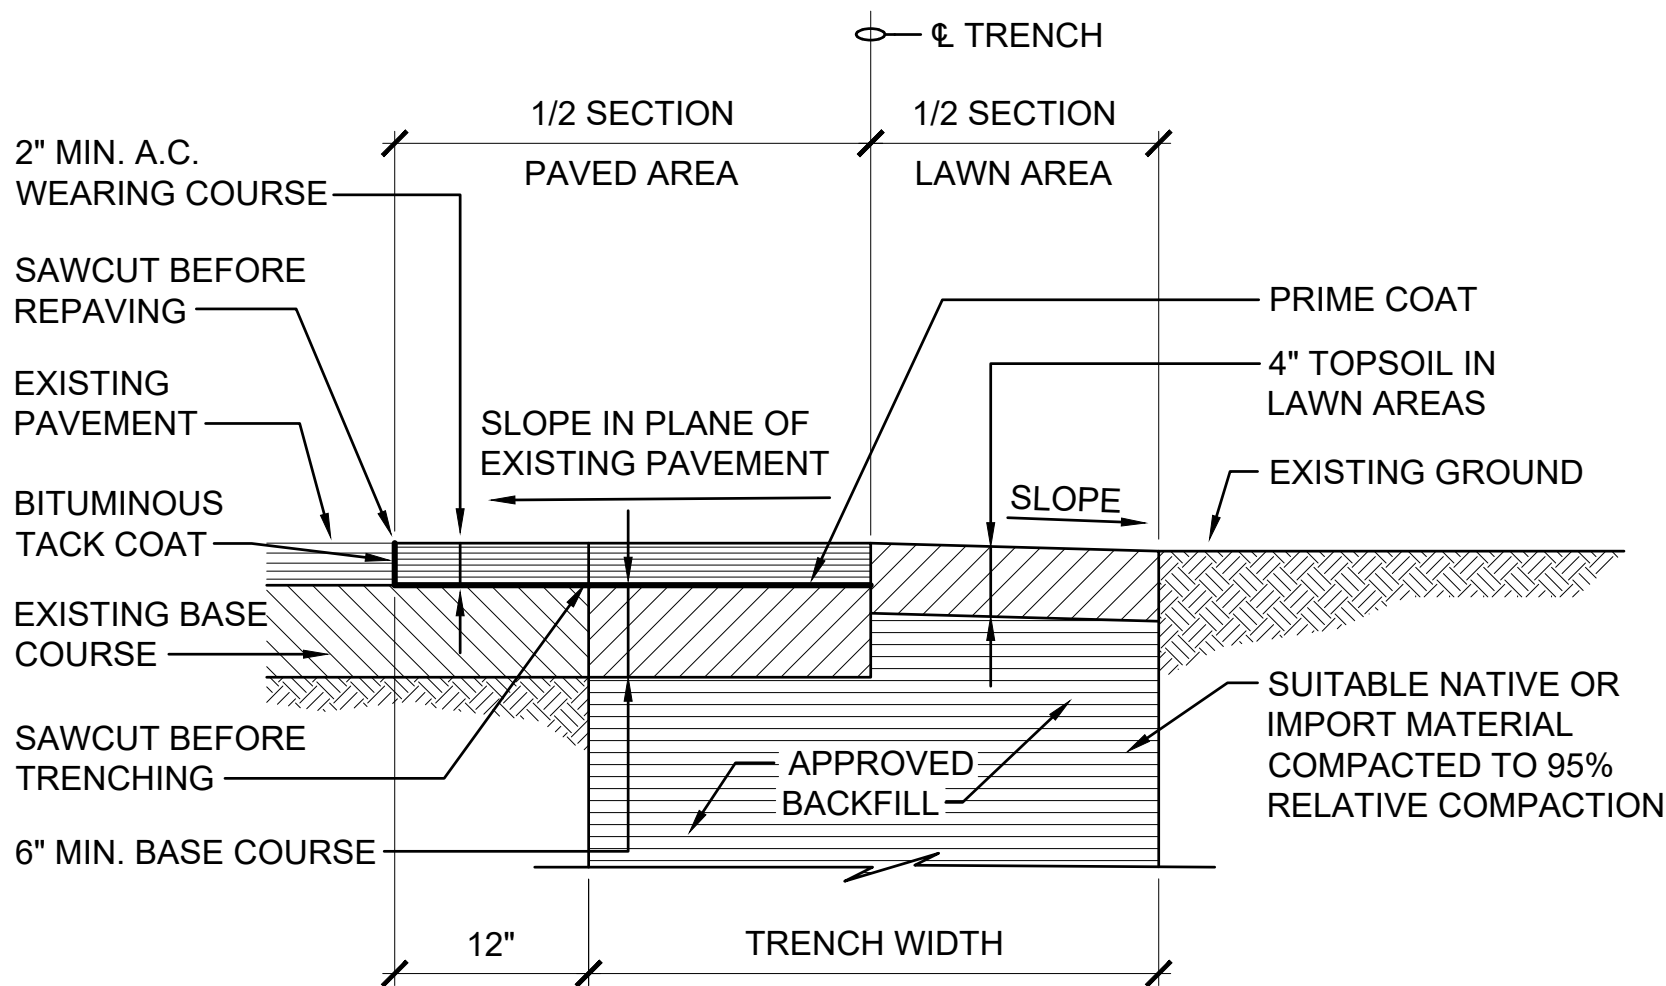


B TRENCH RESTORATION DETAIL
SCALE: NTS

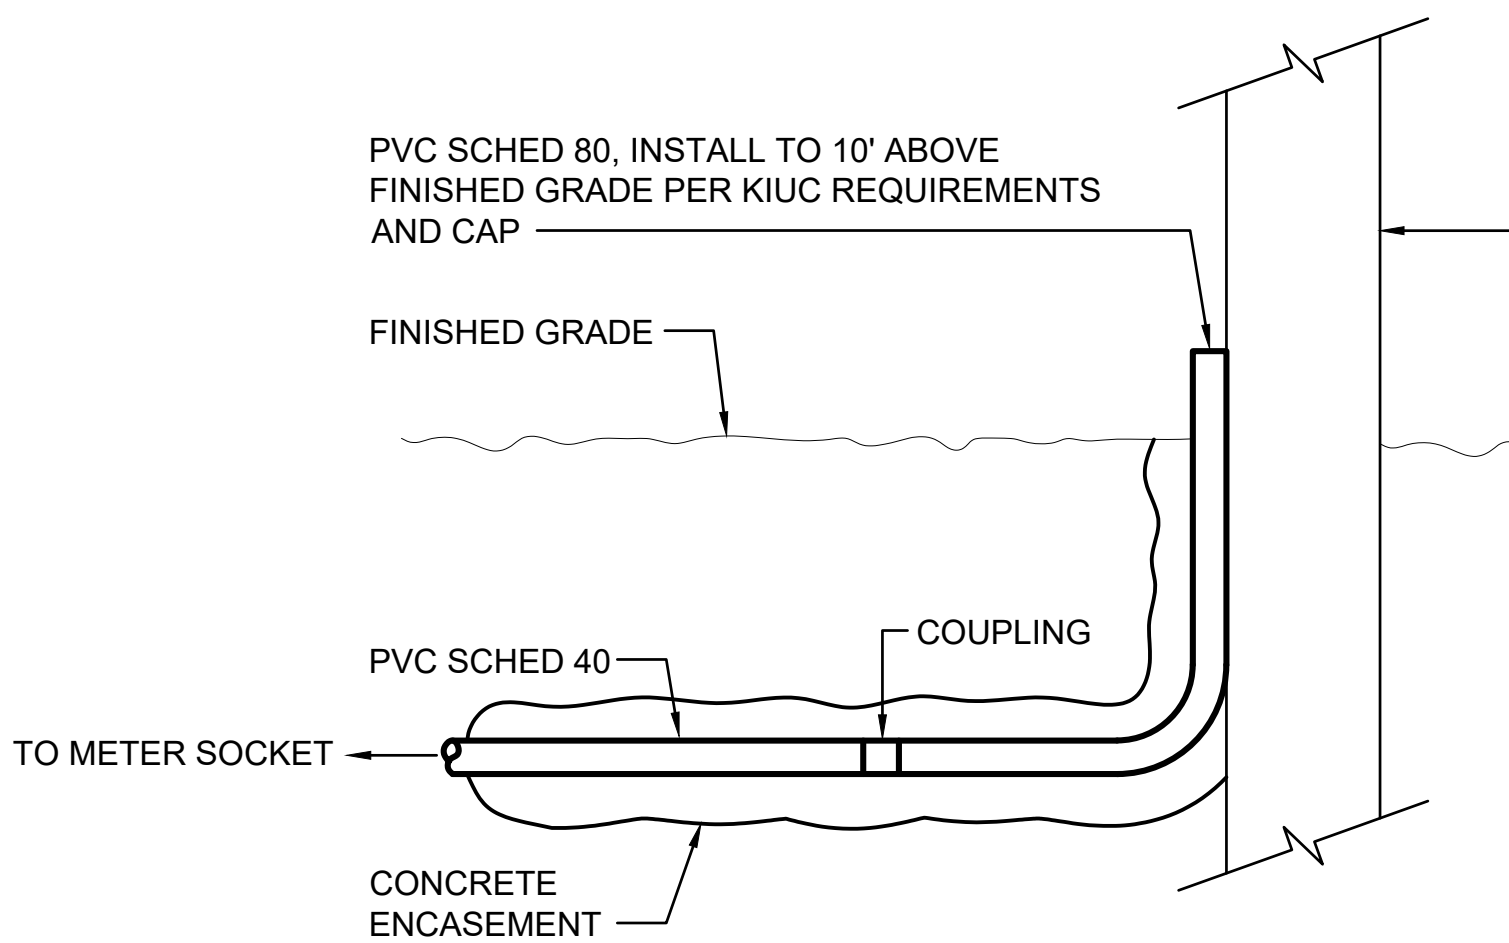

E UNDERGROUND TO EXPOSED TRANSITION DETAIL
SCALE: NTS

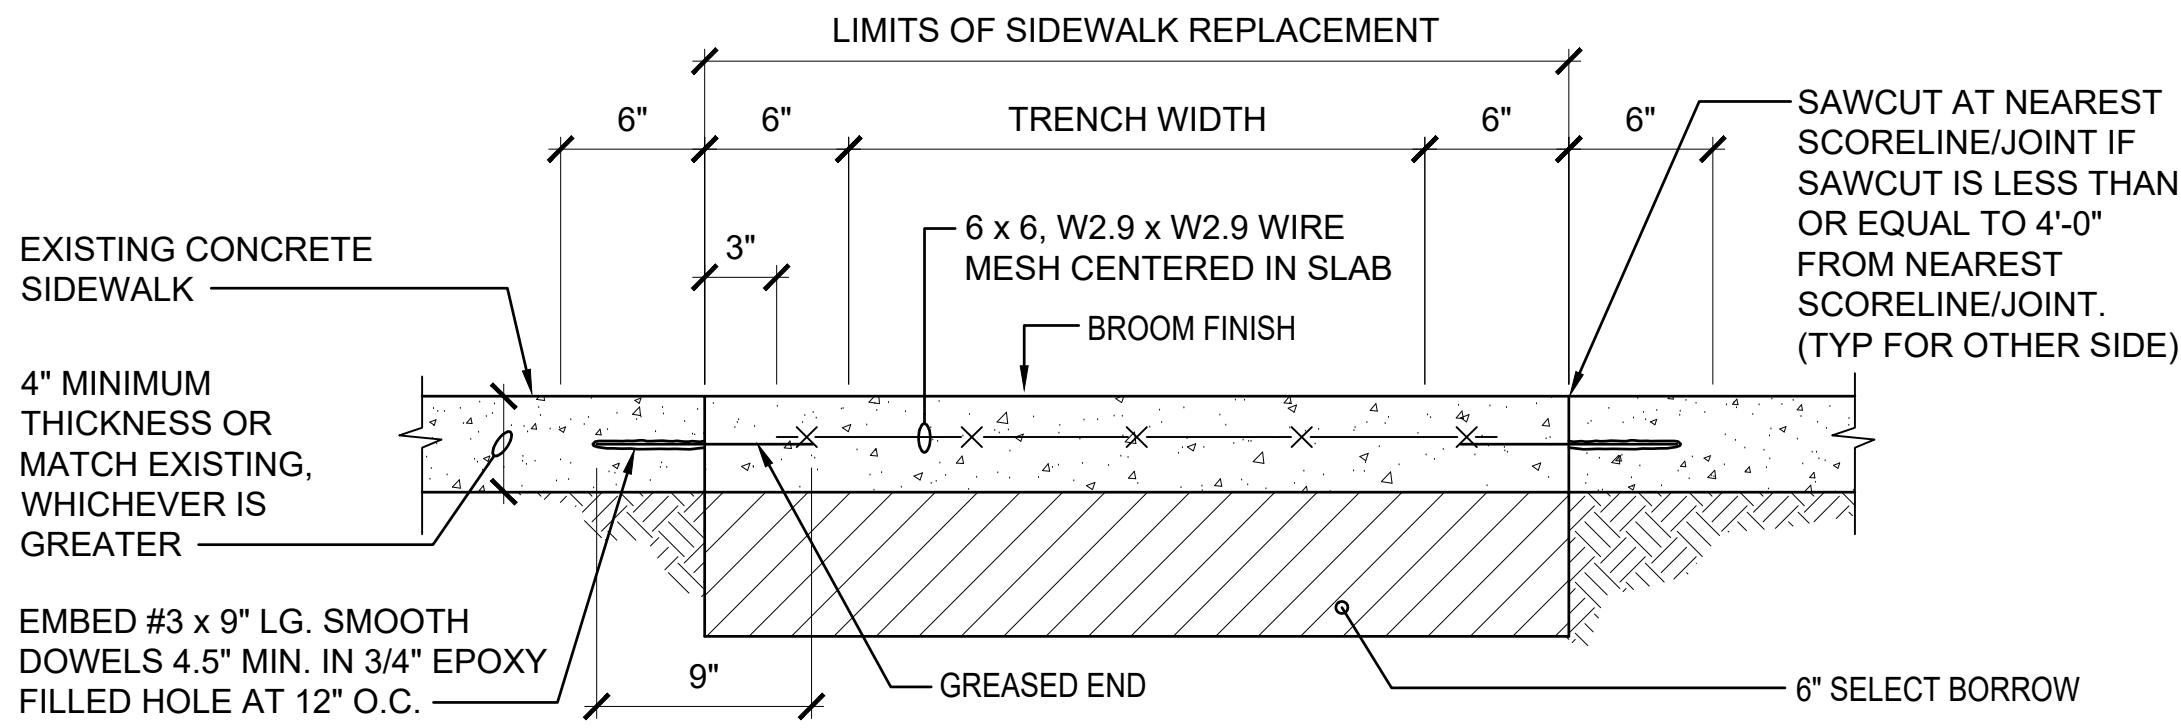

C CONCRETE SIDEWALK RESTORATION DETAIL
SCALE: NTS

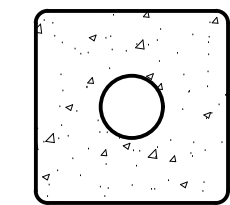


SECTION **A**

F DUCT SECTION DETAILS
SCALE: NTS

- NOTES:
- SEE **A** E-501 FOR ADDITIONAL INFORMATION.

REVISION NO.	SYM.	DESCRIPTION	SHT./OF	DATE	APPROVED
STATE OF HAWAII DEPARTMENT OF LAND AND NATURAL RESOURCES ENGINEERING DIVISION KOKE'E STATE PARK ELECTRICAL IMPROVEMENTS WAIMEA, KAUAI, HAWAII EXTERIOR ELECTRICAL DETAILS FUKUNAGA AND ASSOCIATES, INC					
DESIGNED: ACH			SUBMITTED:		
DRAWN: MKE			DATE: APRIL 2026		
CHECKED: ACH			SCALE: AS SHOWN		
APPROVED: Dina Lau E-signed 2026-05-07 07:15AM HST dina.u.lau@hawaii.gov State of Hawaii Civil Engineer			DRAWING NO. E-501		

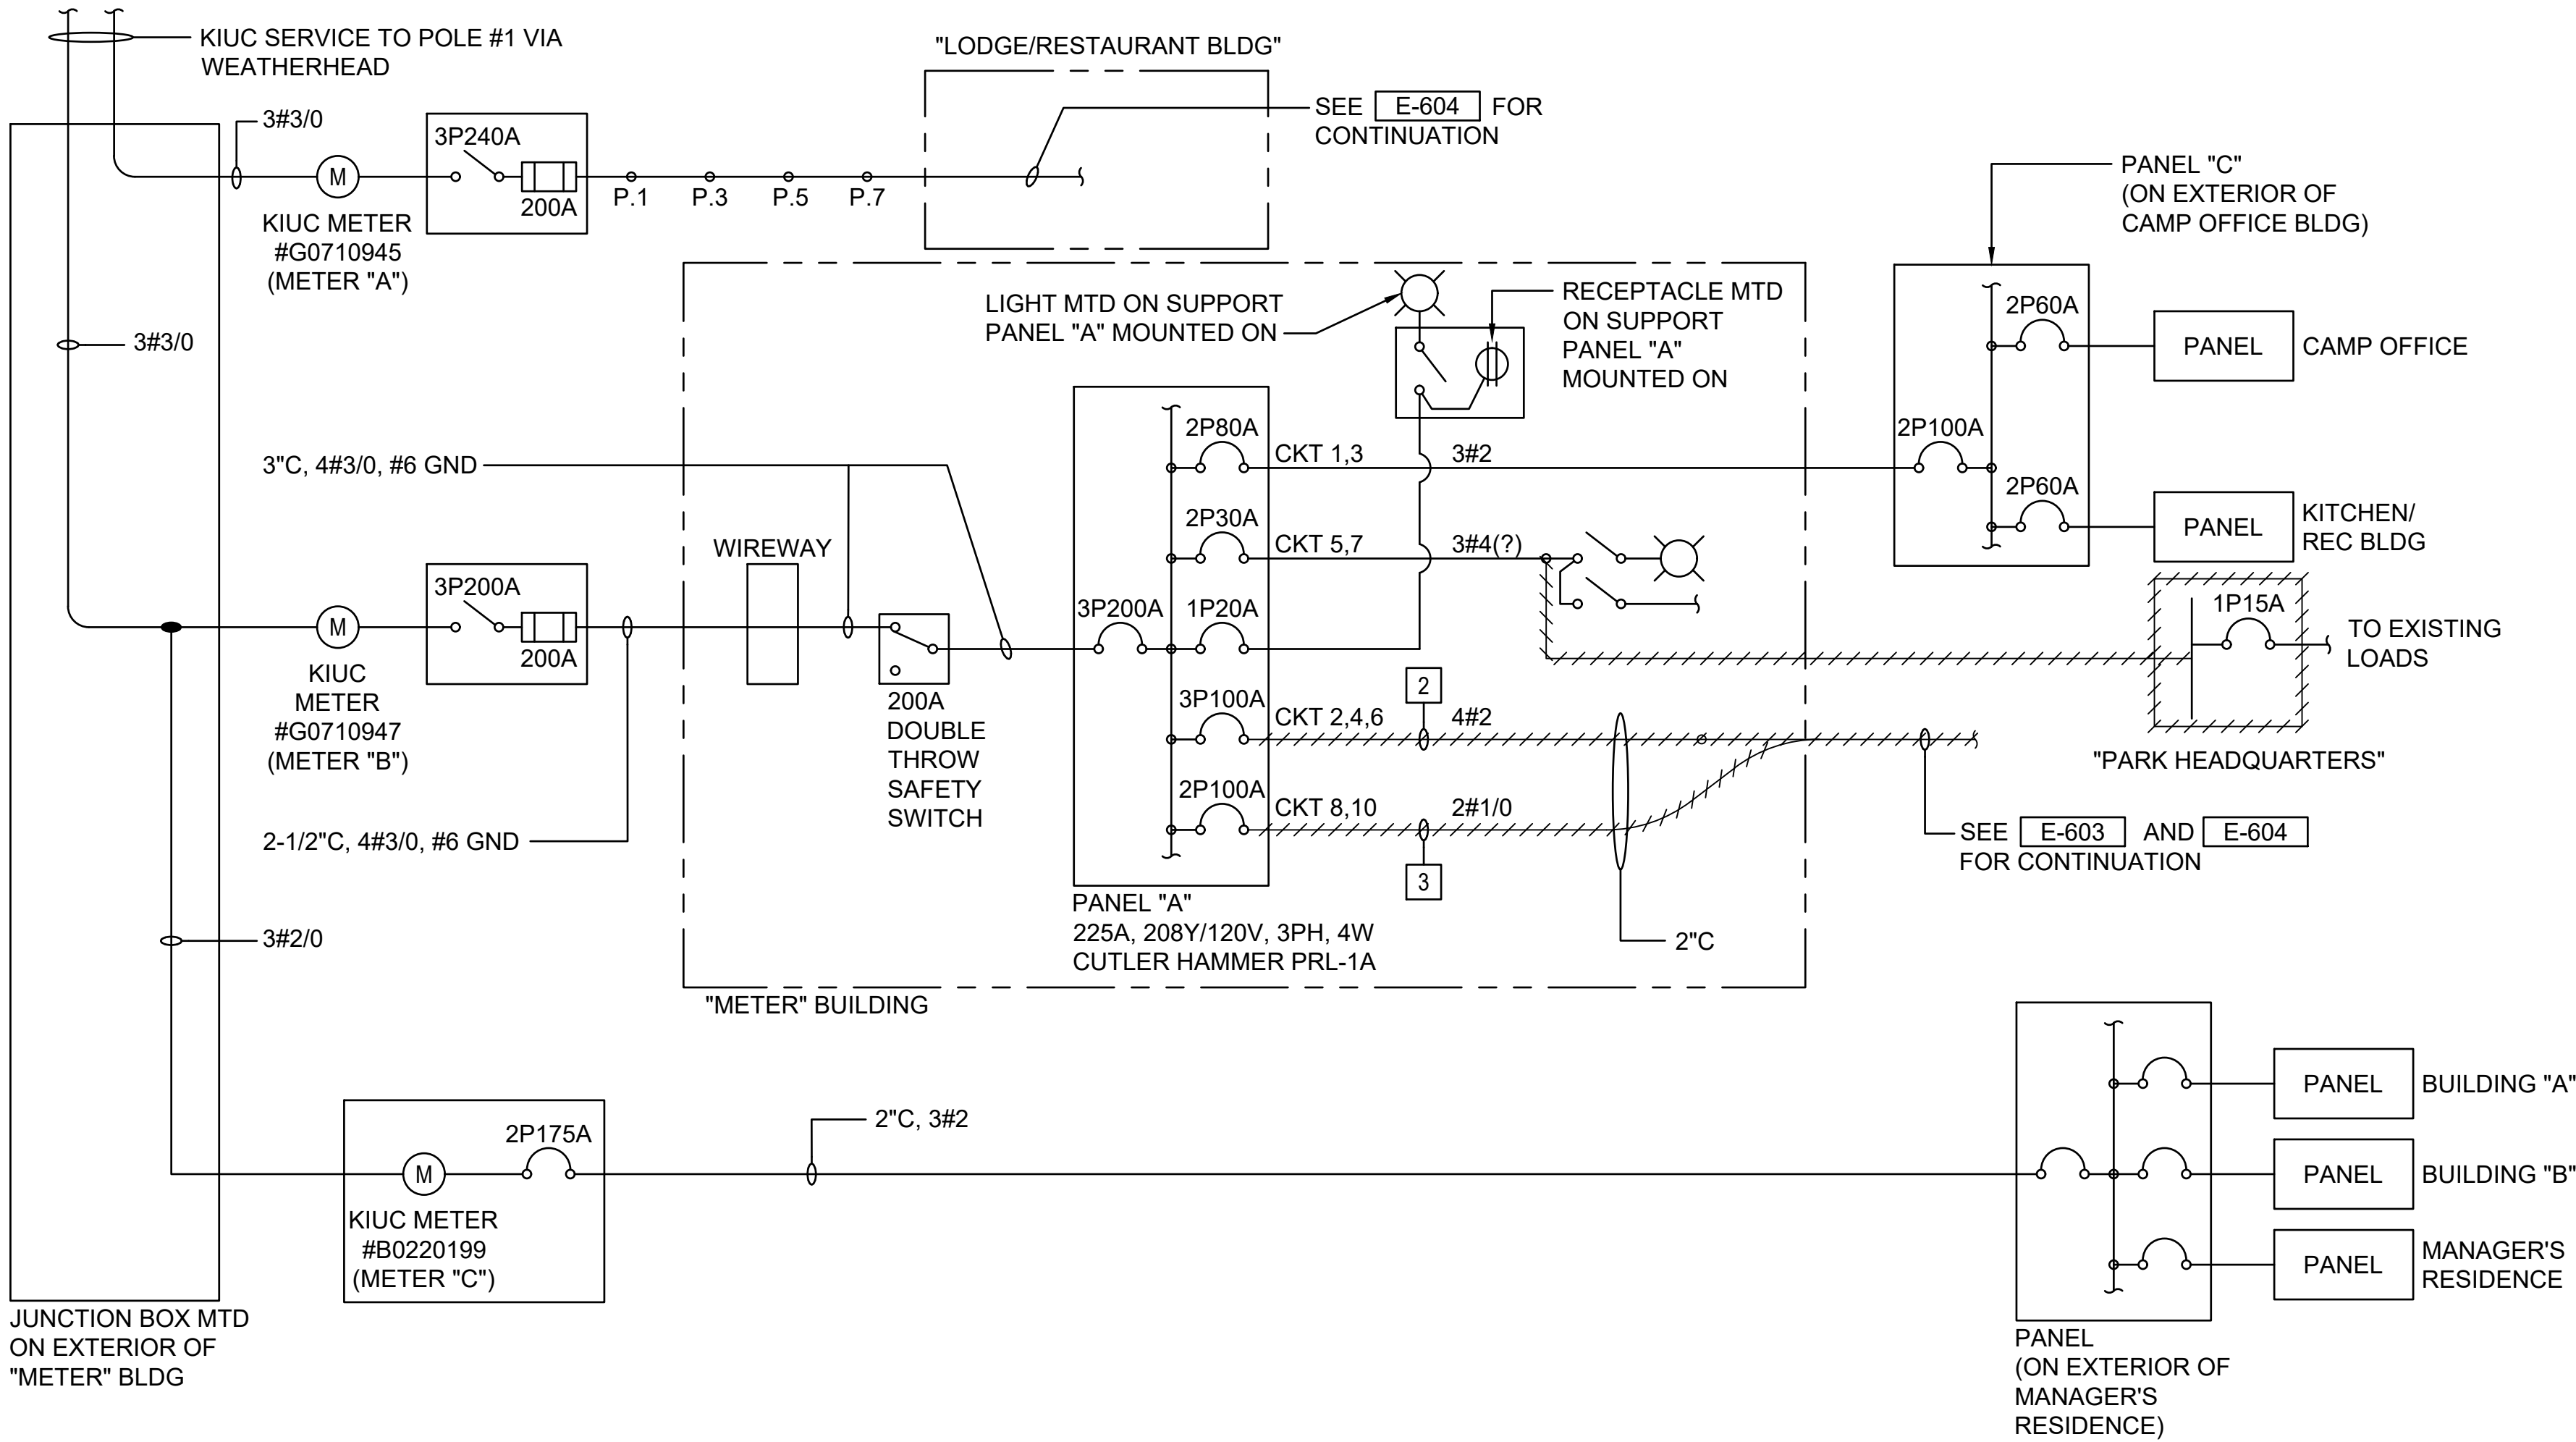


ONE-LINE DIAGRAM - (METERS A, B, C) - DEMO

SCALE: NTS


NOTES:

1. LIGHT LINES DENOTE EXISTING CONDITION
 2. FEEDER FOR GARAGE 1 AND 2.
 3. FEEDER FOR WORKSHOP.
- "I" DENOTES REMOVAL WORK
- "R" DENOTES REMOVAL OF CONDUCTORS FROM EXISTING CONDUIT. CONDUIT TO BE REUSED.

REVISION NO.	SYM.	DESCRIPTION	SHT./OF	DATE	APPROVED
STATE OF HAWAII DEPARTMENT OF LAND AND NATURAL RESOURCES ENGINEERING DIVISION					
KOKE'E STATE PARK ELECTRICAL IMPROVEMENTS WAIMEA, KAUAI, HAWAII					
ONE-LINE DIAGRAM - (METERS A, B, C) - DEMO					
FUKUNAGA AND ASSOCIATES, INC					
DESIGNED: ACH			SUBMITTED:		
DRAWN: MKE			DATE: APRIL 2026		
CHECKED: ACH			SCALE: AS SHOWN		
APPROVED: Dina Lau E-signed 2026-05-07 07:15AM HST dina.u.lau@hawaii.gov State of Hawaii Civil Engineer			DRAWING NO. E-601		

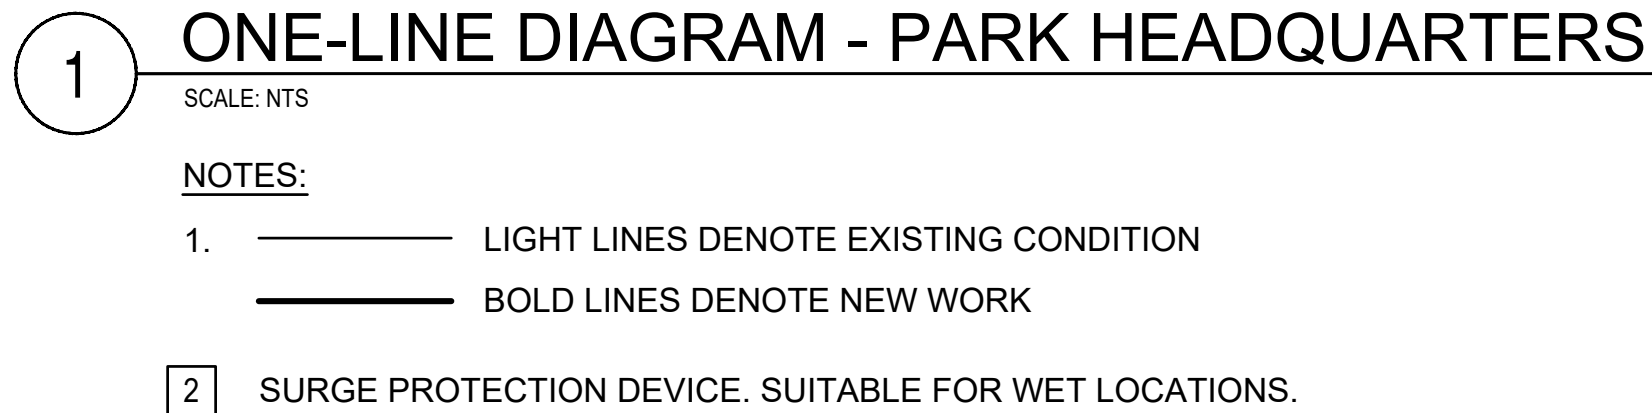

JOB NO. F46C602F SHEET NO. 18 OF 21 SHEETS

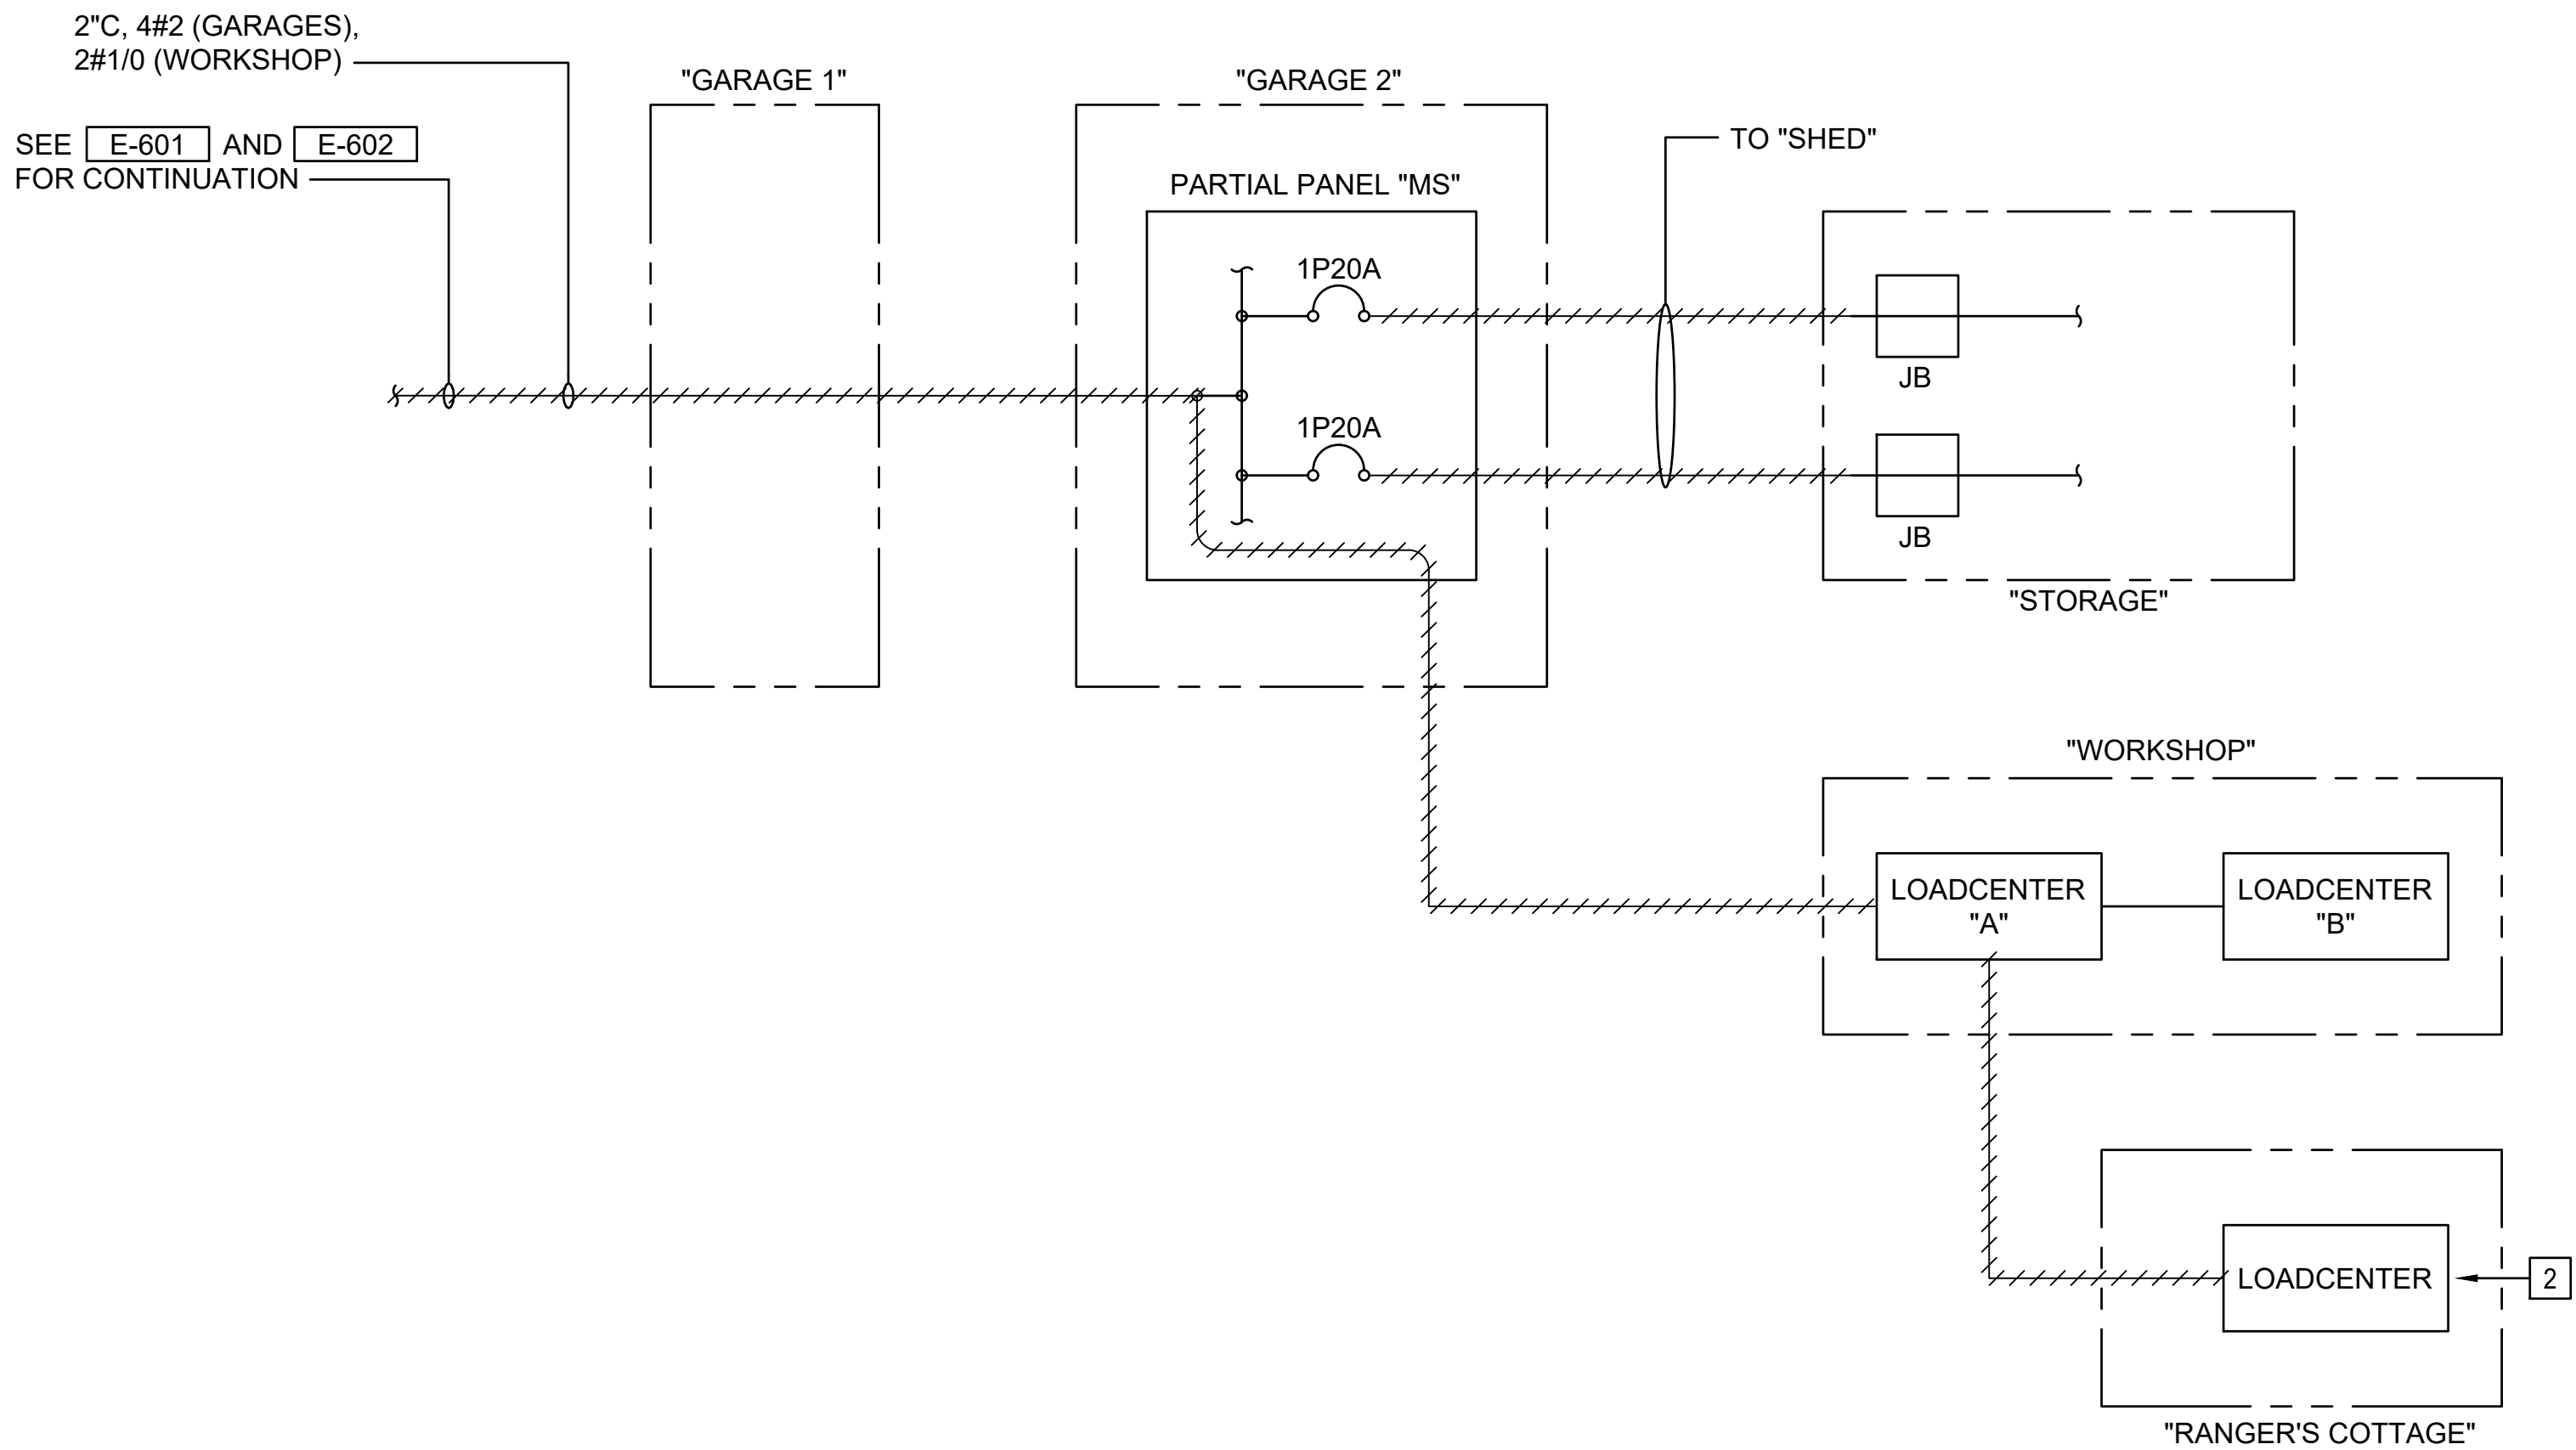


1 ONE-LINE DIAGRAM - GARAGES/STORAGE/WORKSHOP/RANGER'S COTTAGE - DEMO

SCALE: NTS

NOTES:

1. LIGHT LINES DENOTE EXISTING CONDITION
- BOLD LINES DENOTE NEW WORK
- "/" DENOTES REMOVAL WORK
- "R" DENOTES REMOVAL OF CONDUCTORS FROM EXISTING CONDUIT. CONDUIT TO BE REUSED.
- 2 CONVERT TO JUNCTION BOX. PRESERVE EXISTING BRANCH CIRCUIT CONDUCTORS FOR RECONNECTION. REMOVE SURFACE RUST FROM ENCLOSURE AND PAINT. PROVIDE NEW BLANK COVER.

REVISION NO.	SYM.	DESCRIPTION	SHT./OF	DATE	APPROVED
STATE OF HAWAII DEPARTMENT OF LAND AND NATURAL RESOURCES ENGINEERING DIVISION KOKE'E STATE PARK ELECTRICAL IMPROVEMENTS WAIMEA, KAUAI, HAWAII ONE-LINE DIAGRAM - MAINT SHED-SHED-KOKEE LODGE STORAGE - DEMO FUKUNAGA AND ASSOCIATES, INC					
DESIGNED: ACH		SUBMITTED:			
DRAWN: MKE		DATE: APRIL 2026			
CHECKED: ACH		SCALE: AS SHOWN		DRAWING NO. E-603	
APPROVED: Dina Lau E-signed 2026-05-07 07:15AM HST dina.u.lau@hawaii.gov State of Hawaii Civil Engineer		CHIEF ENGINEER			

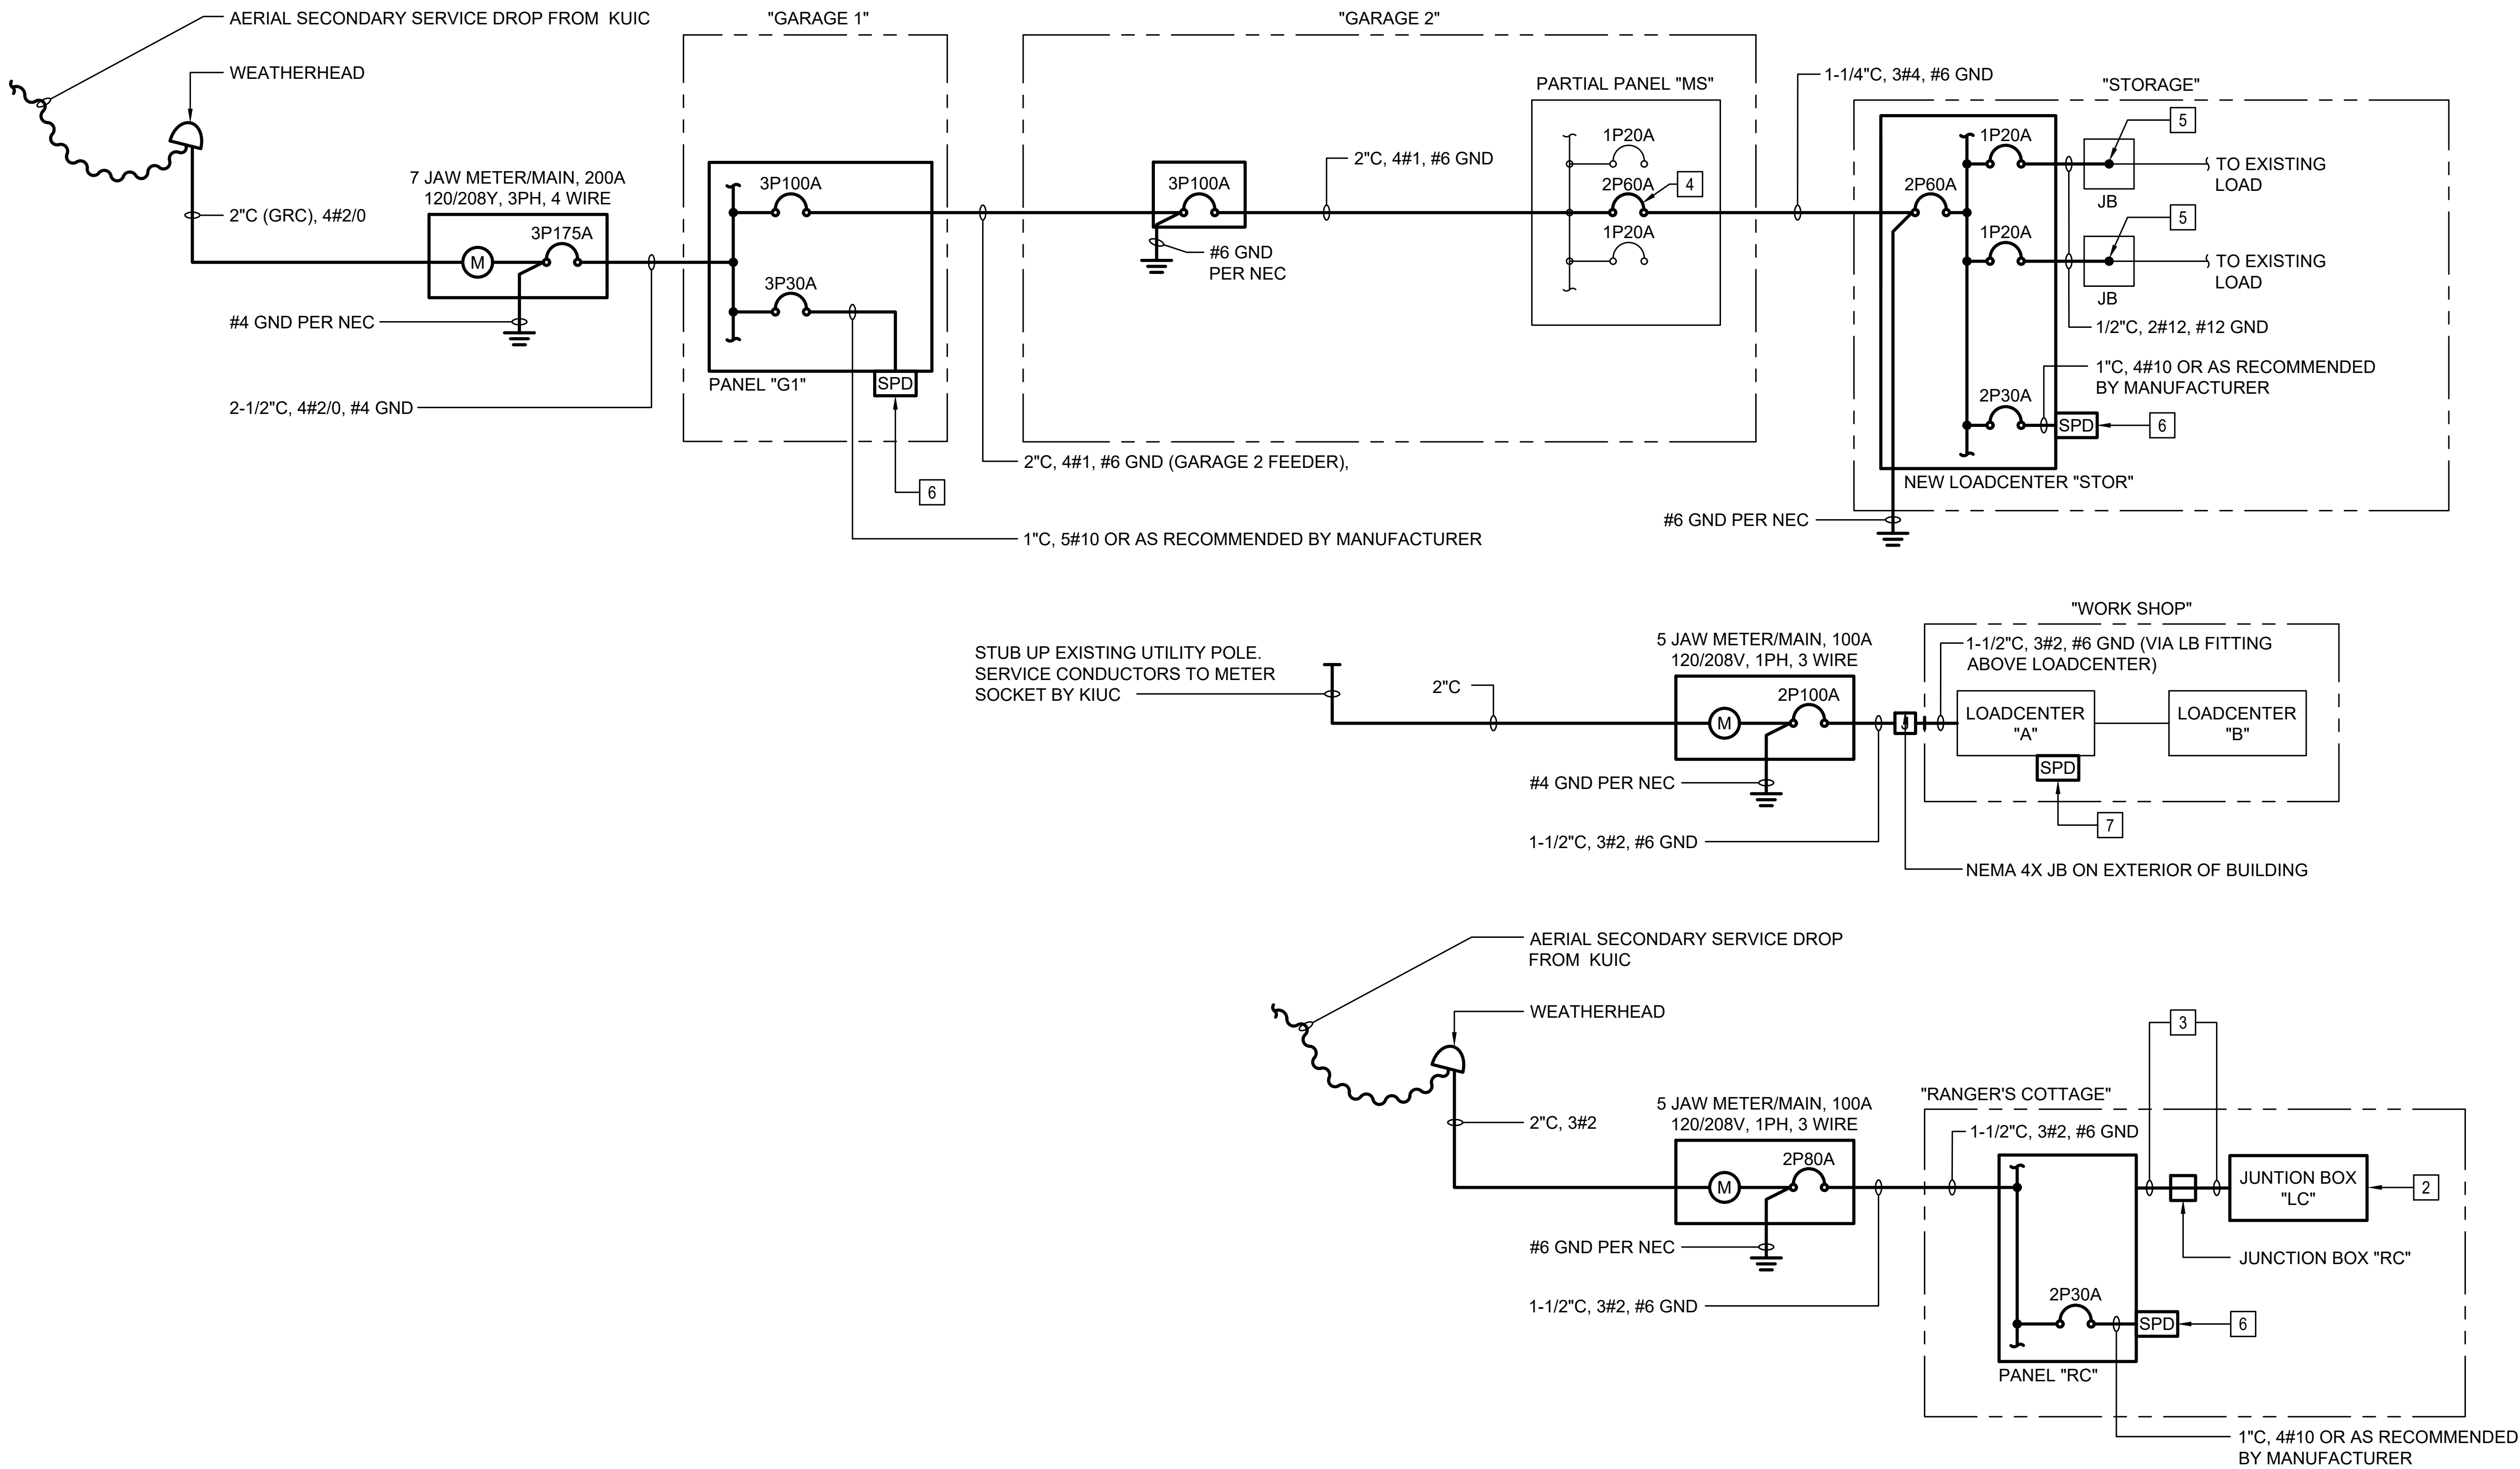

1 ONE-LINE DIAGRAM - GARAGES/STORAGE/WORKSHOP/RANGER'S COTTAGE

SCALE: NTS

NOTES:

1. ——— LIGHT LINES DENOTE EXISTING CONDITION
——— BOLD LINES DENOTE NEW WORK
- 2 EXISTING LOADCENTER CONVERTED TO JUNCTION BOX. RECONNECT EXISTING BRANCH CIRCUITS VIA NEW LOADCENTER.
- 3 1/2"C, 2#12, #12 GND (FOR 2P20A BKR),
1/2"C, 2#12, #12 GND (FOR 2P20A BKR),
1/2"C, 2#12, #12 GND (FOR 2P20A BKR),
3/4"C, 2#10, #10 GND (FOR 2P30A BKR),
3/4"C, 6#12, #12 GND (FOR 1P BKRS, 3 EACH).
- 4 PROVIDE NEW CIRCUIT BREAKER IN EXISTING PANELBOARD (WESTINGHOUSE TYPE NQP).
- 5 SPLICE TO EXISTING CONDUCTORS.
- 6 SURGE PROTECTION DEVICE. SUITABLE FOR WET LOCATIONS.
- 7 SURGE PROTECTION DEVICE CONNECTED DIRECTLY TO LOADCENTER BUS. 4#10 OR AS RECOMMENDED BY MANUFACTURER.

REVISION NO.	SYM.	DESCRIPTION	SHT./OF	DATE	APPROVED
STATE OF HAWAII DEPARTMENT OF LAND AND NATURAL RESOURCES ENGINEERING DIVISION					
KOKE'E STATE PARK ELECTRICAL IMPROVEMENTS WAIMEA, KAUAI, HAWAII					
ONE-LINE DIAGRAM - MAINT SHED-SHED-KOKEE LODGE STORAGE FUKUNAGA AND ASSOCIATES, INC					
DESIGNED: ACH			SUBMITTED:		
DRAWN: MKE			DATE: APRIL 2026		
CHECKED: ACH			SCALE: AS SHOWN		
APPROVED: Dina Lau E-signed 2026-05-07 07:15AM HST dina.u.lau@hawaii.gov State of Hawaii CHIEF ENGINEER			DRAWING NO. E-604		

